



QLD 5227 NEIL LOGAN 2709 BRIAN DONOVAN 1595 MARK GRIMMER 5528 DAVID KELLY 3866 KEVIN O'BRIEN 7115 JULIAN ASHTON 7053 MATTHEW BLAIR 7151 PHILLIP ROSSINGTON 7439 PETER TITMUSS 10447 ALISON BOUNDS 10705 CATHERINE SKINNER Phone: +61 2 8297 7200 Fax: +61 2 8297 7299 Website: www.bvn.com.au

CONTRACTOR TO CHECK AND VERIFY ALL DIMENSIONS ON SITE PRIOR

ORIGINAL DRAWING

IN COLOUR

15 25.02.22 STAGE 3 50%DD 16 15.04.22 50% DESIGN PACKAGE 4 - D&C TRADE PACKAGE TENDER 17 27.06.22 75% DESIGN PACKAGE 3 18 26.08.22 75% DESIGN PACKAGE 3 19 23.09.22 50% DESIGN PACKAGE 6 20 30.09.22 75% DESIGN PACKAGE 3 21 07.10.22 50% DESIGN PACKAGE 6 22 28.10.22 50% DESIGN PACKAGE 6 23 23.11.22 DP3 FOR INFORMATION A 22.03.23 AFC DESIGN PACKAGE 3
B 28.03.23 AFC CC2 / DP3

FWT-XXX EXTERNAL WALL SYSTEM CODE - REFER AR-43 SERIES FOR SCOPE, & FACADE ENGINEER'S DOCUMENTS FOR SPECIFICATION DETAIL

LXX.DXX) DOOR TAG; REFER DOOR SCHEDULES WALL TAG; REFER INTERNAL WALL TYPES SCHEDULE

AR-52A-XXX-01 RETAINED EXISTING BUILT ELEMENTS SHOWN AS SOLID TOWN PLANNER ELECTRICAL, FIRE SAFETY & HYDRAULIC TEL +61 2 8233 9900 TEL +61 2 8484 7000 LANDSCAPE ARCHITECT FIRE ENGINEER

Holmes Fire

TEL +61 2 9264 4658

ASPECT Studios

TEL +61 2 9699 7182

DDA CONSULTANT Morris Goding Access Consulting TEL +61 2 9692 9322

PROJECT MANAGER Generate TEL +61 433 706 275 PROJECT ATLASSIAN CENTRAL No.8-10 LEE STREET, HAYMARKET

PROJECT NUMBER


1906024


1:250@A1 STATUS


FOR CONSTRUCTION


GENERAL ARRANGEMENT PLAN BASEMENT 2 DOCUMENT NUMBER


AR-09B-B00-00

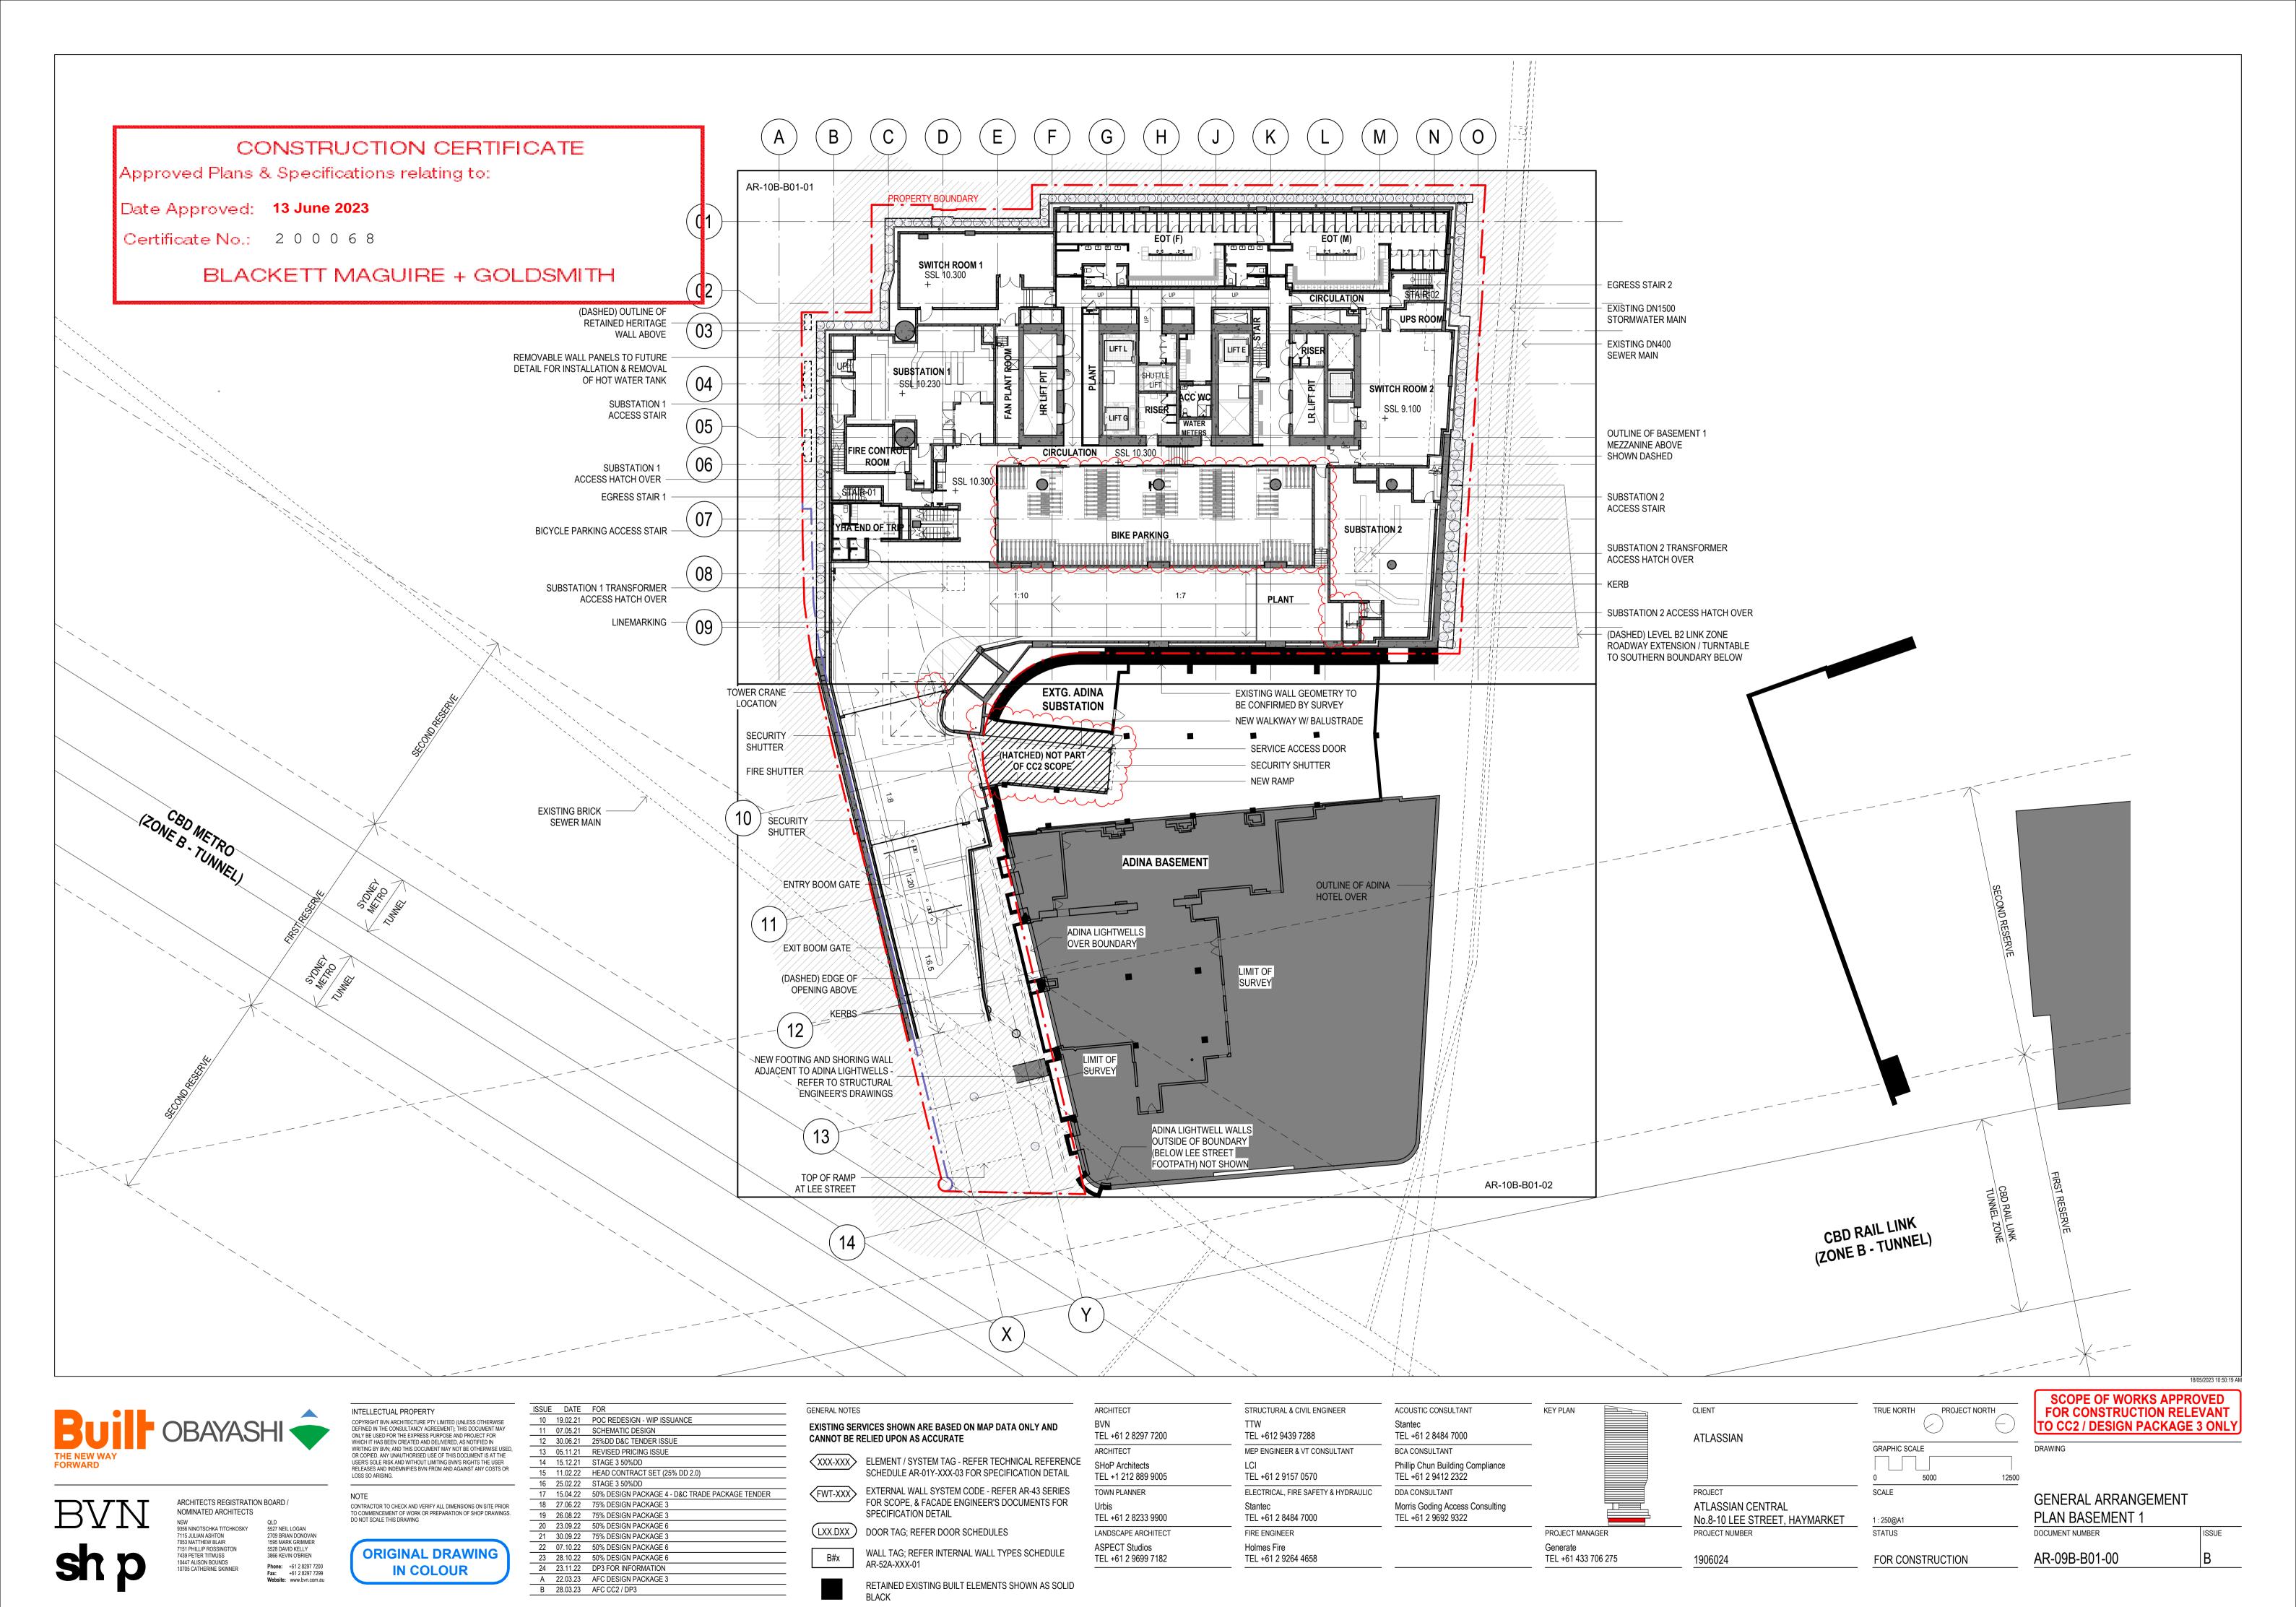


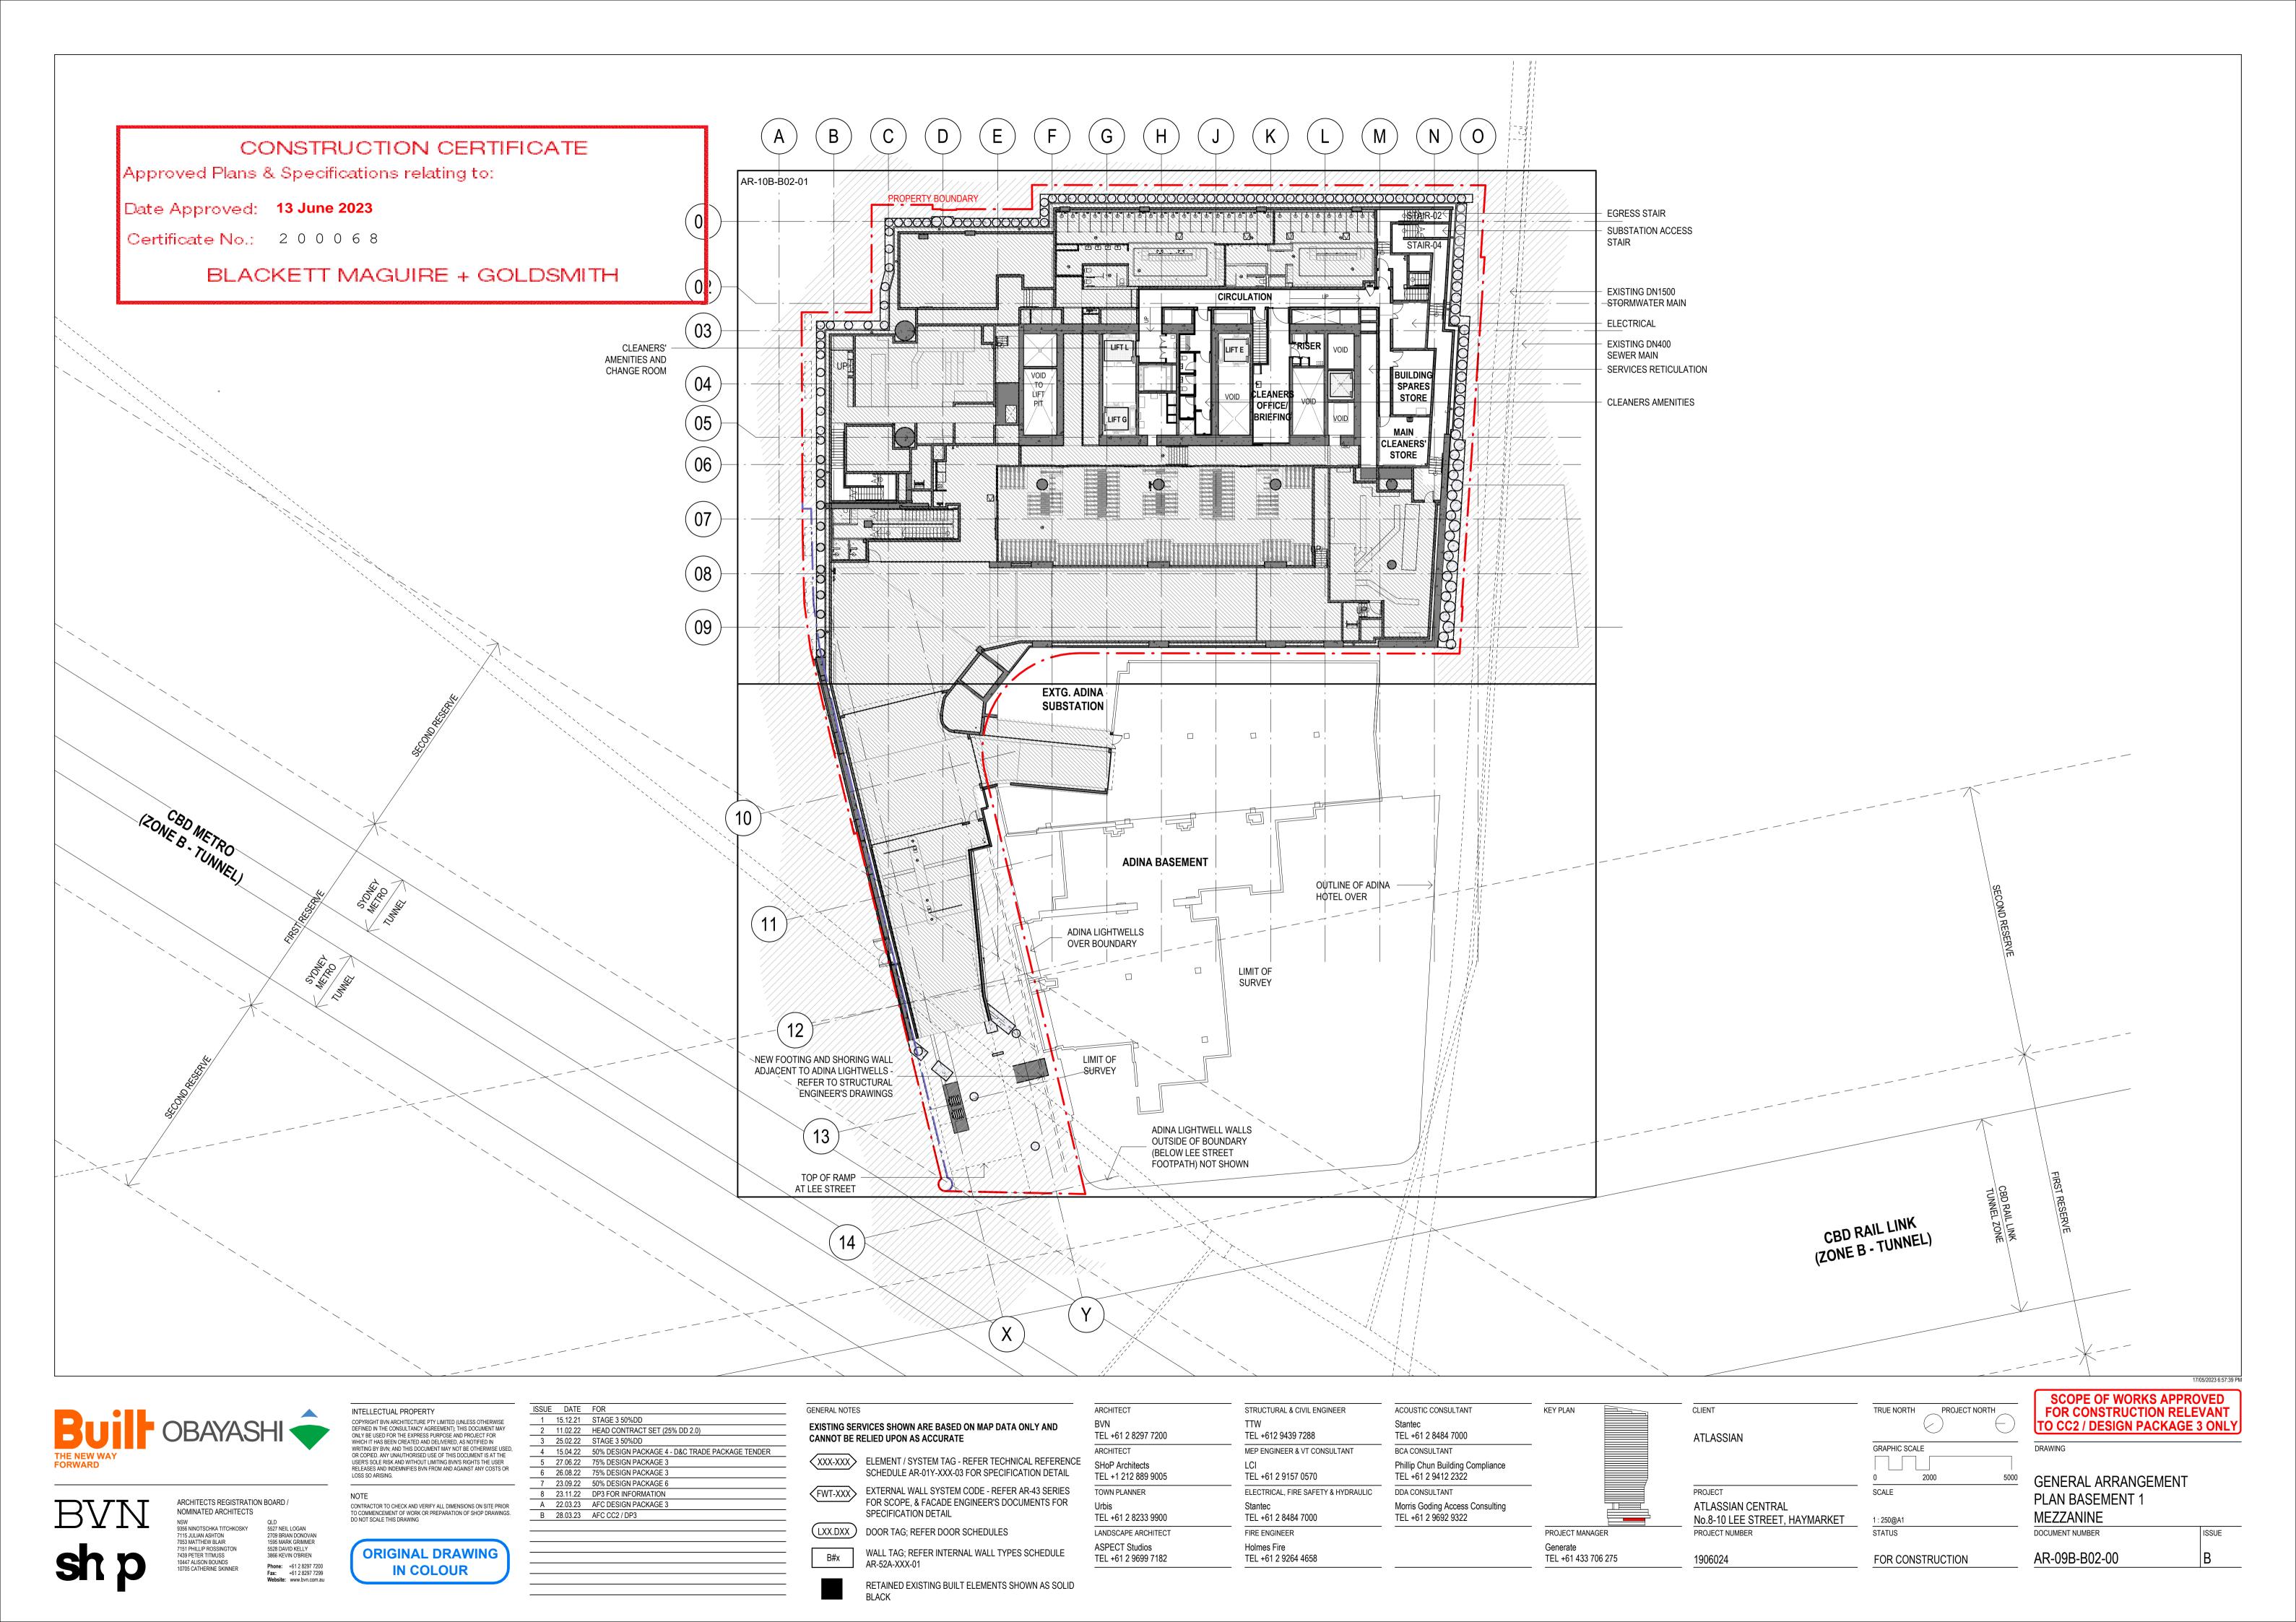


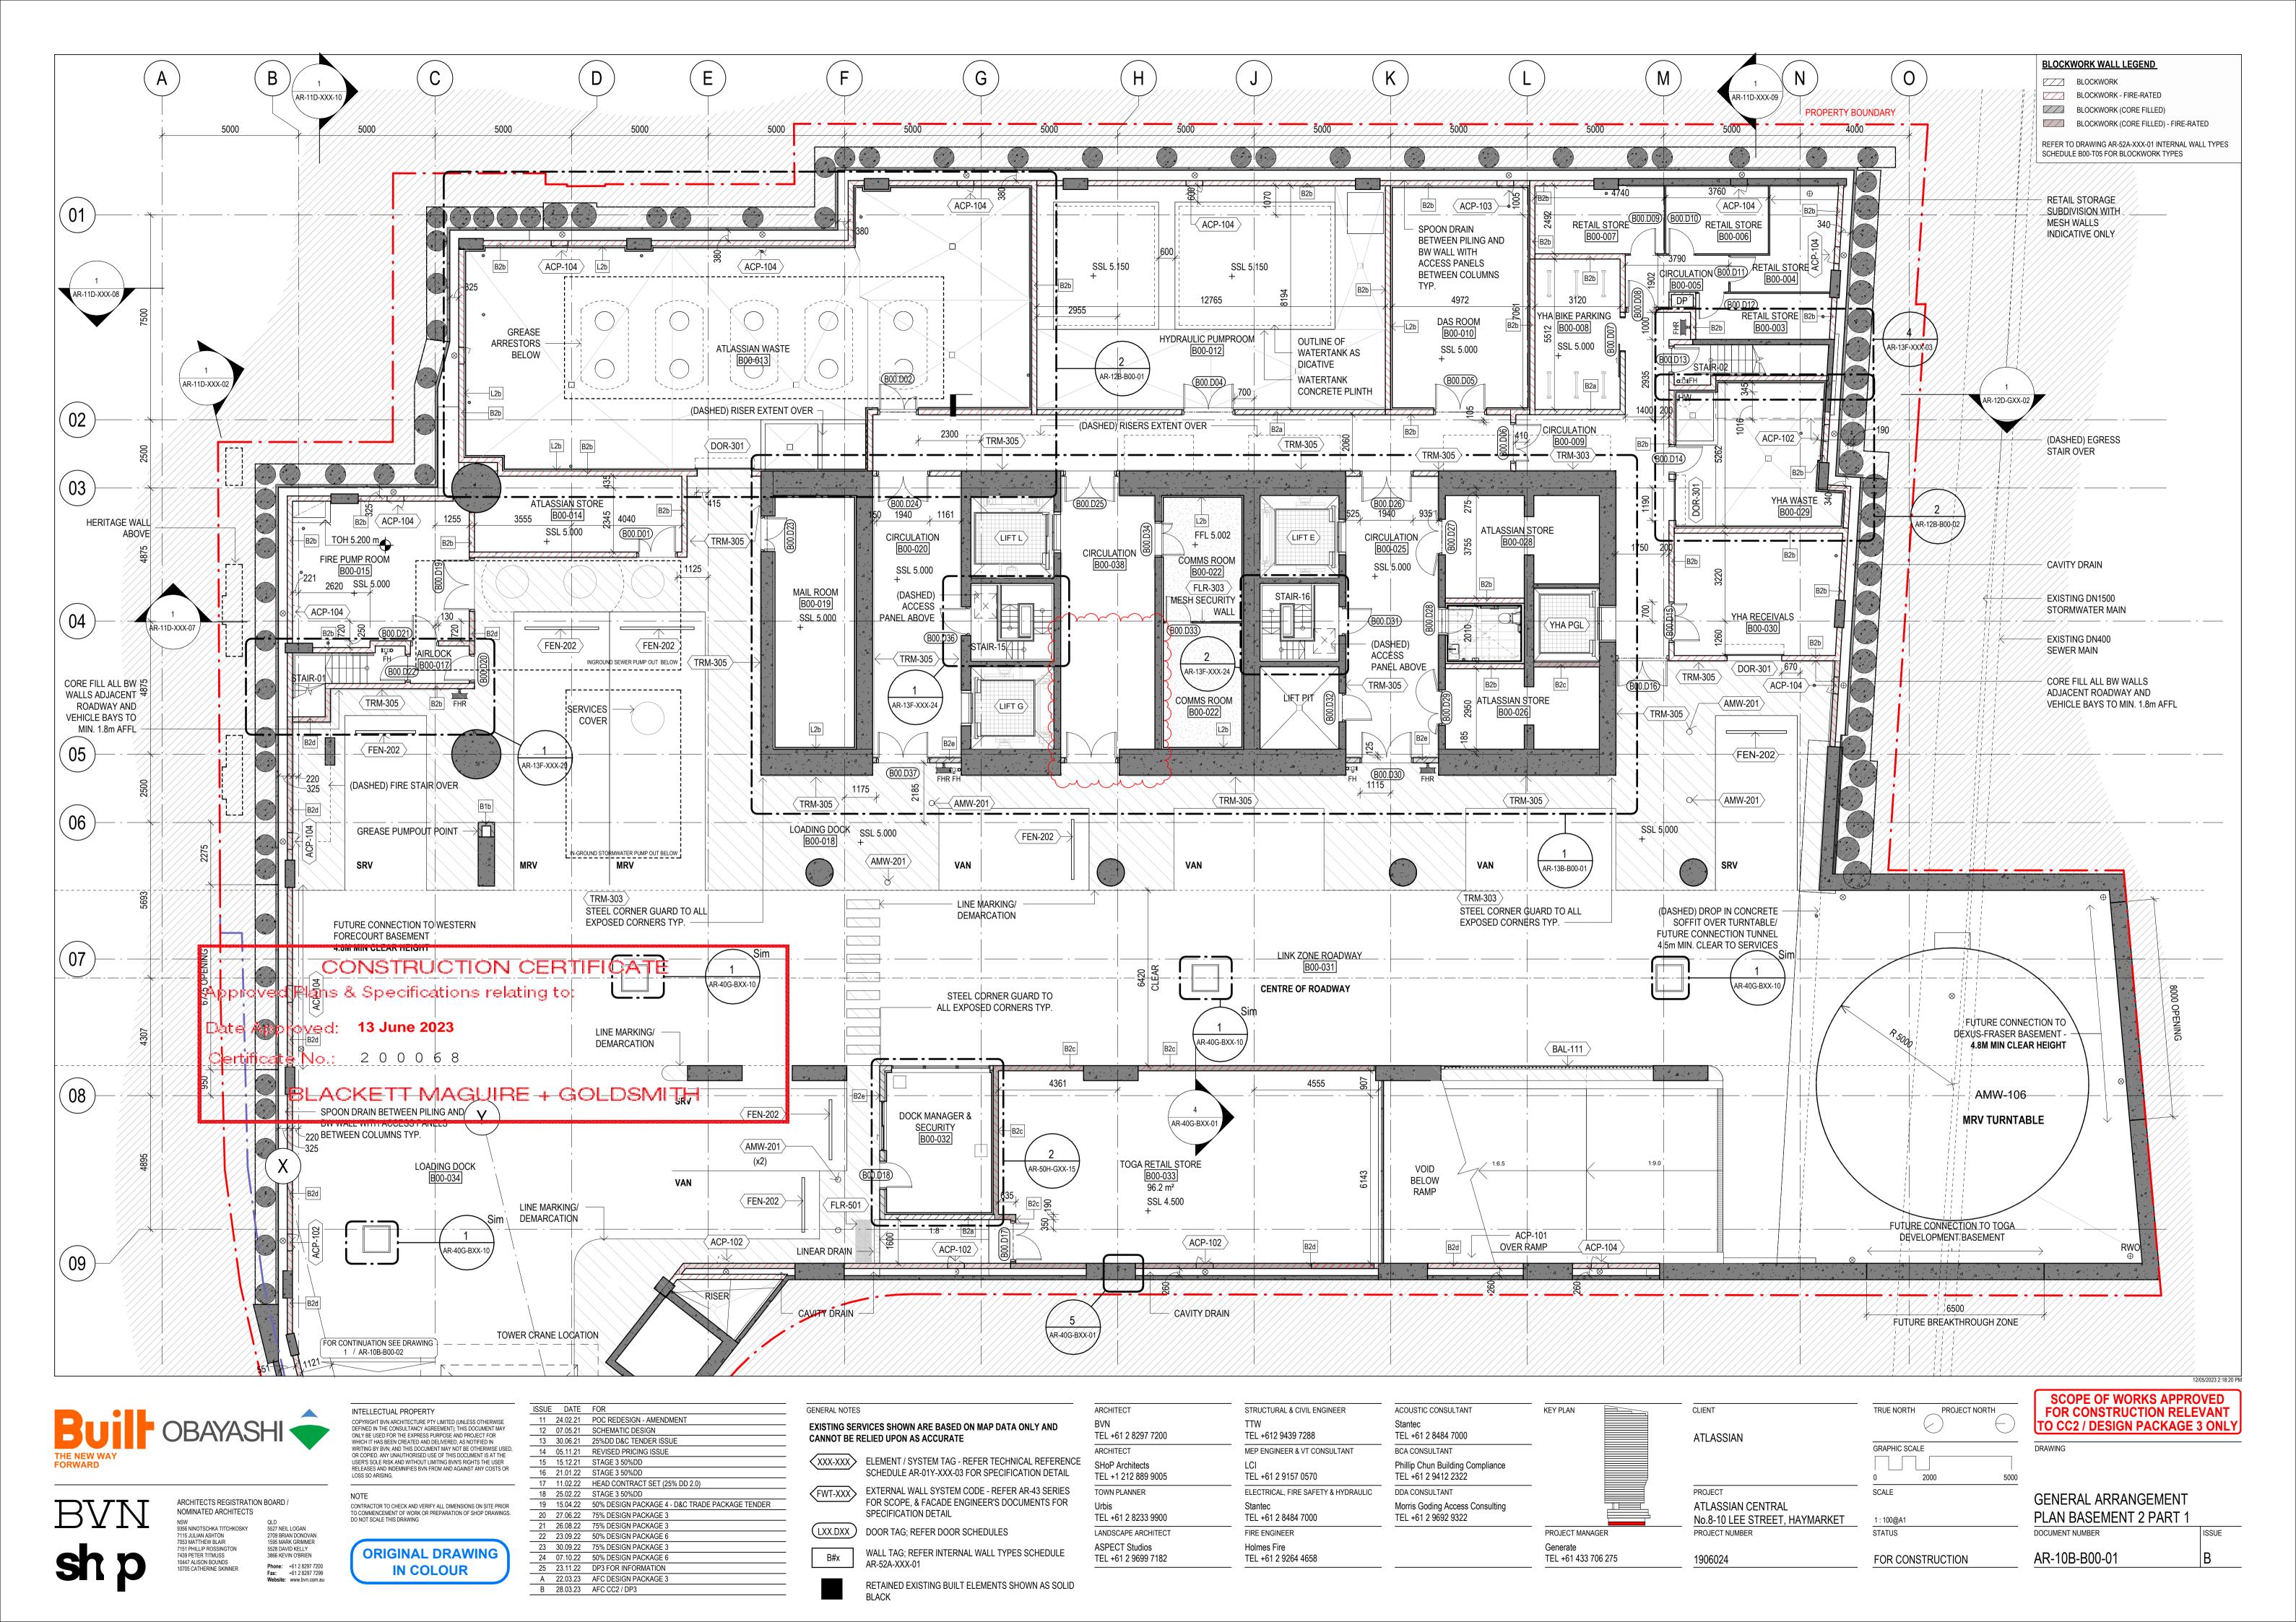


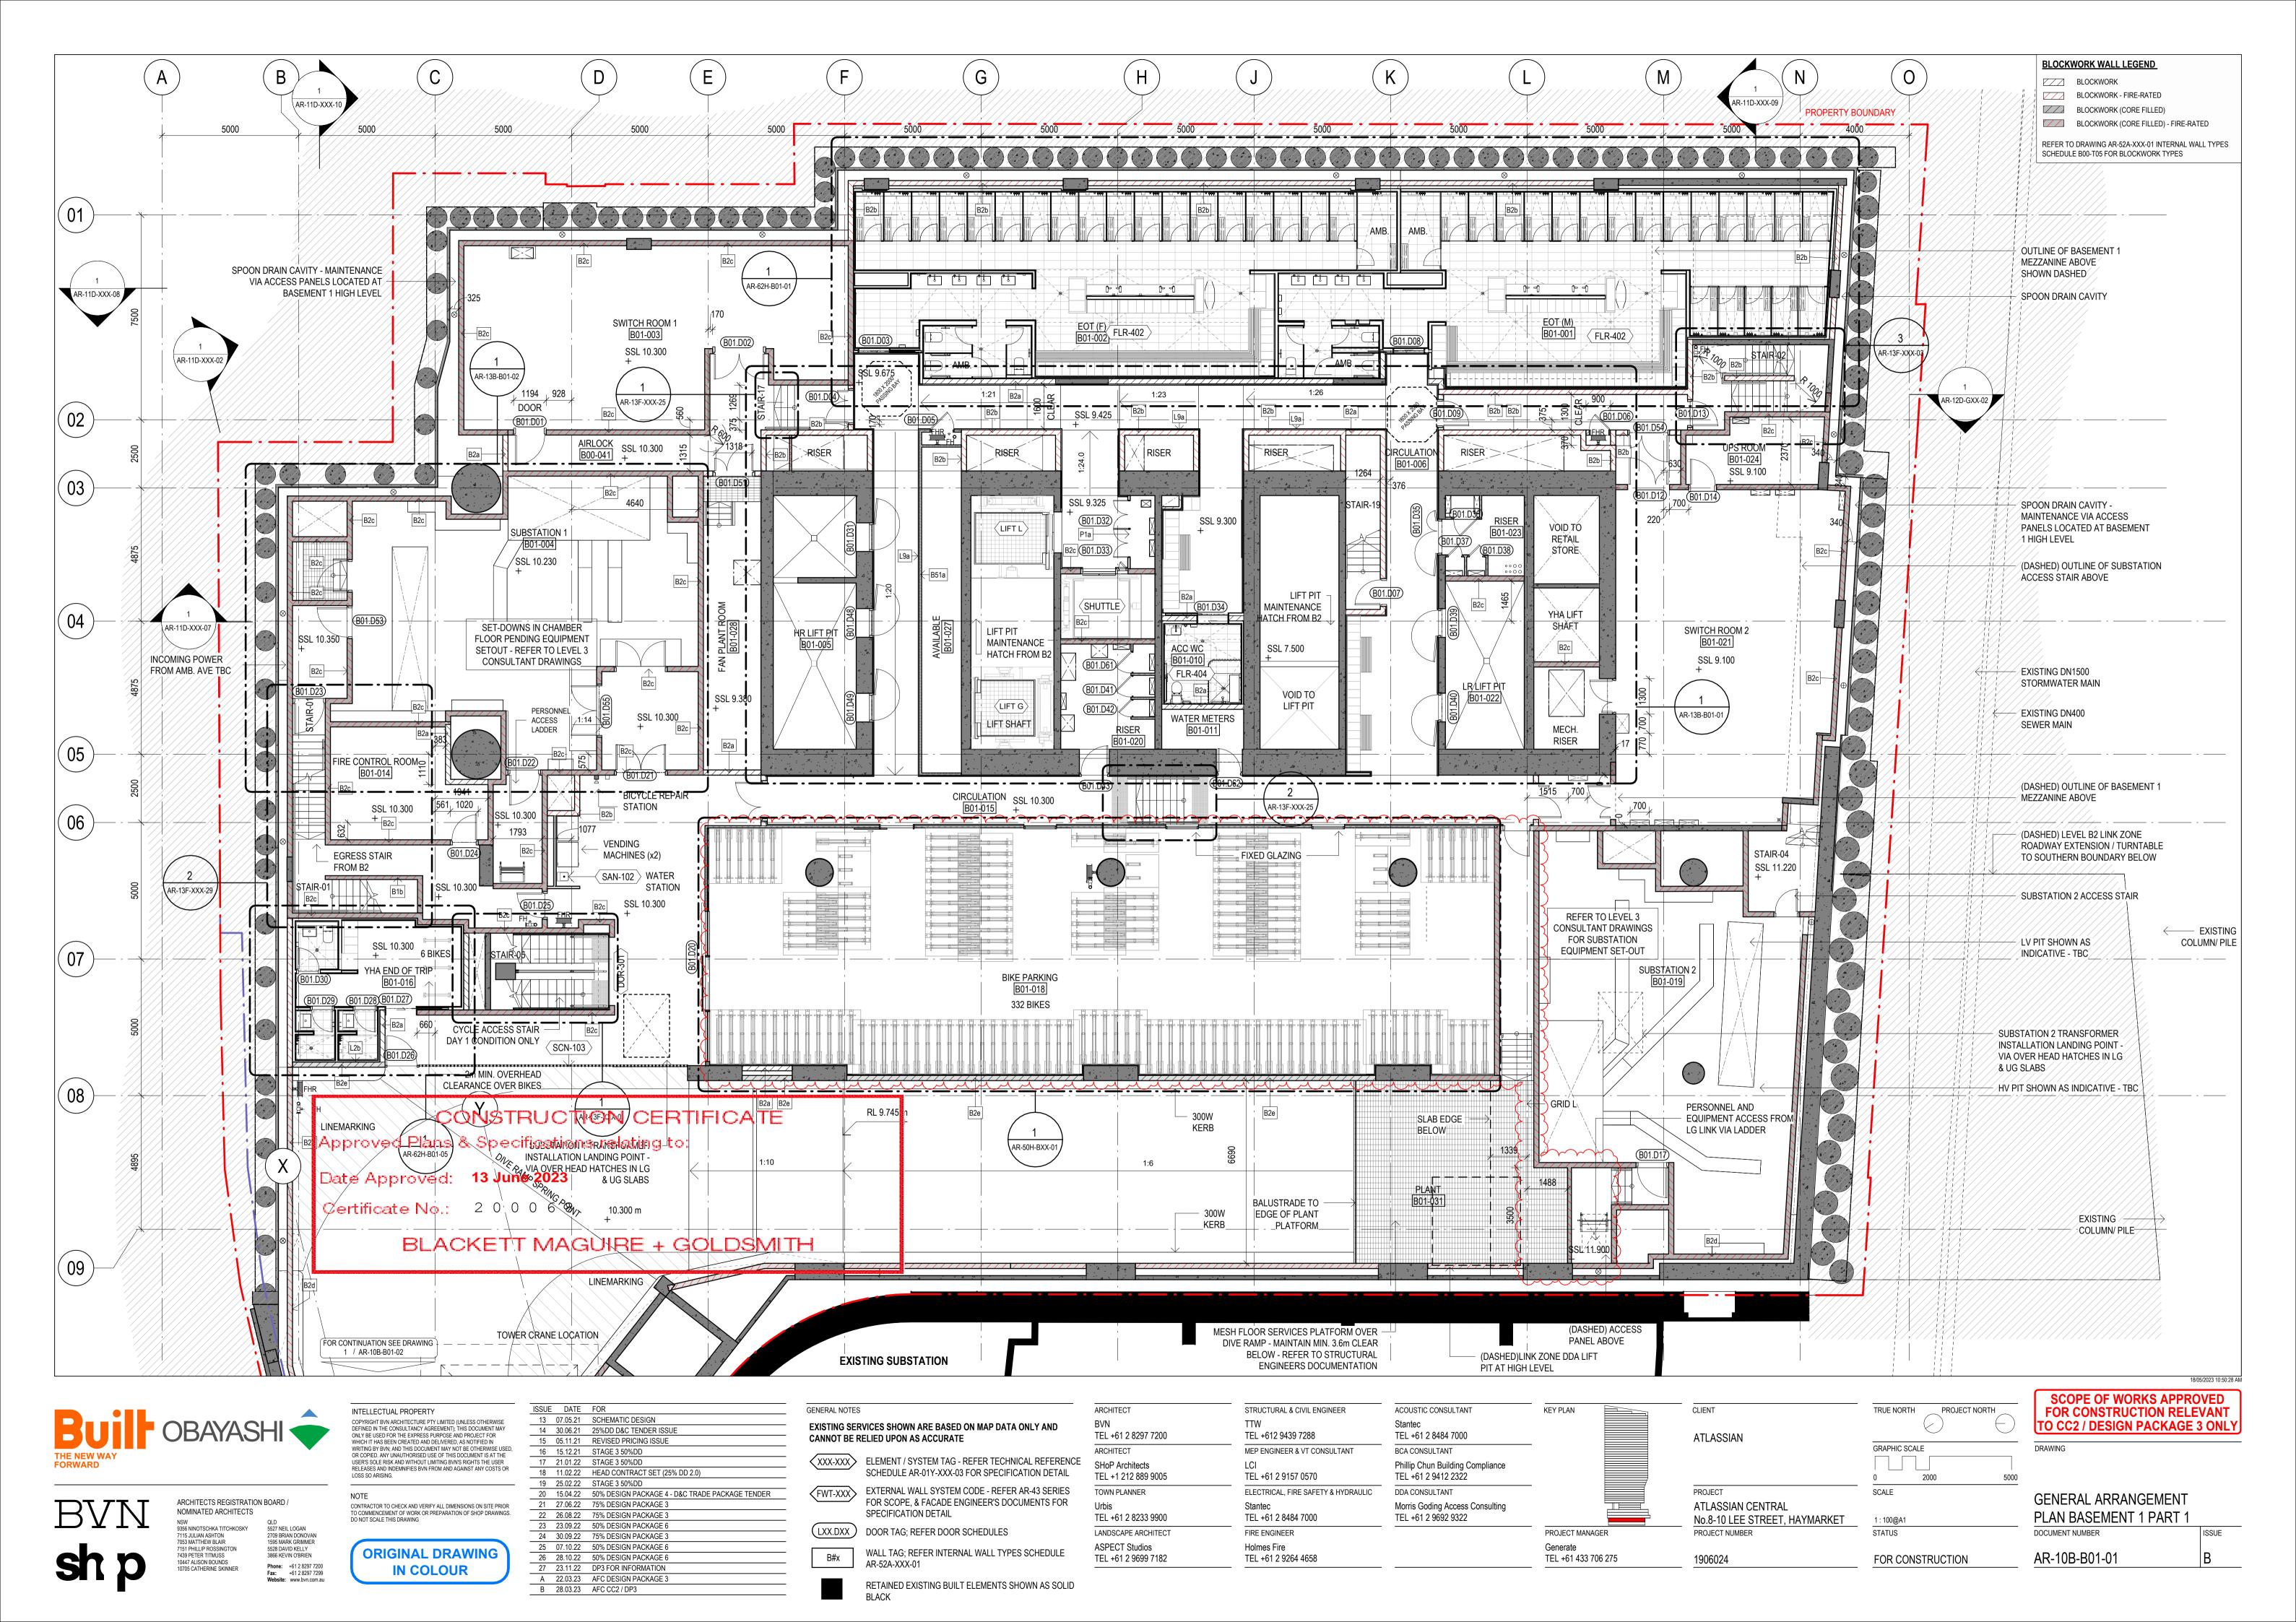


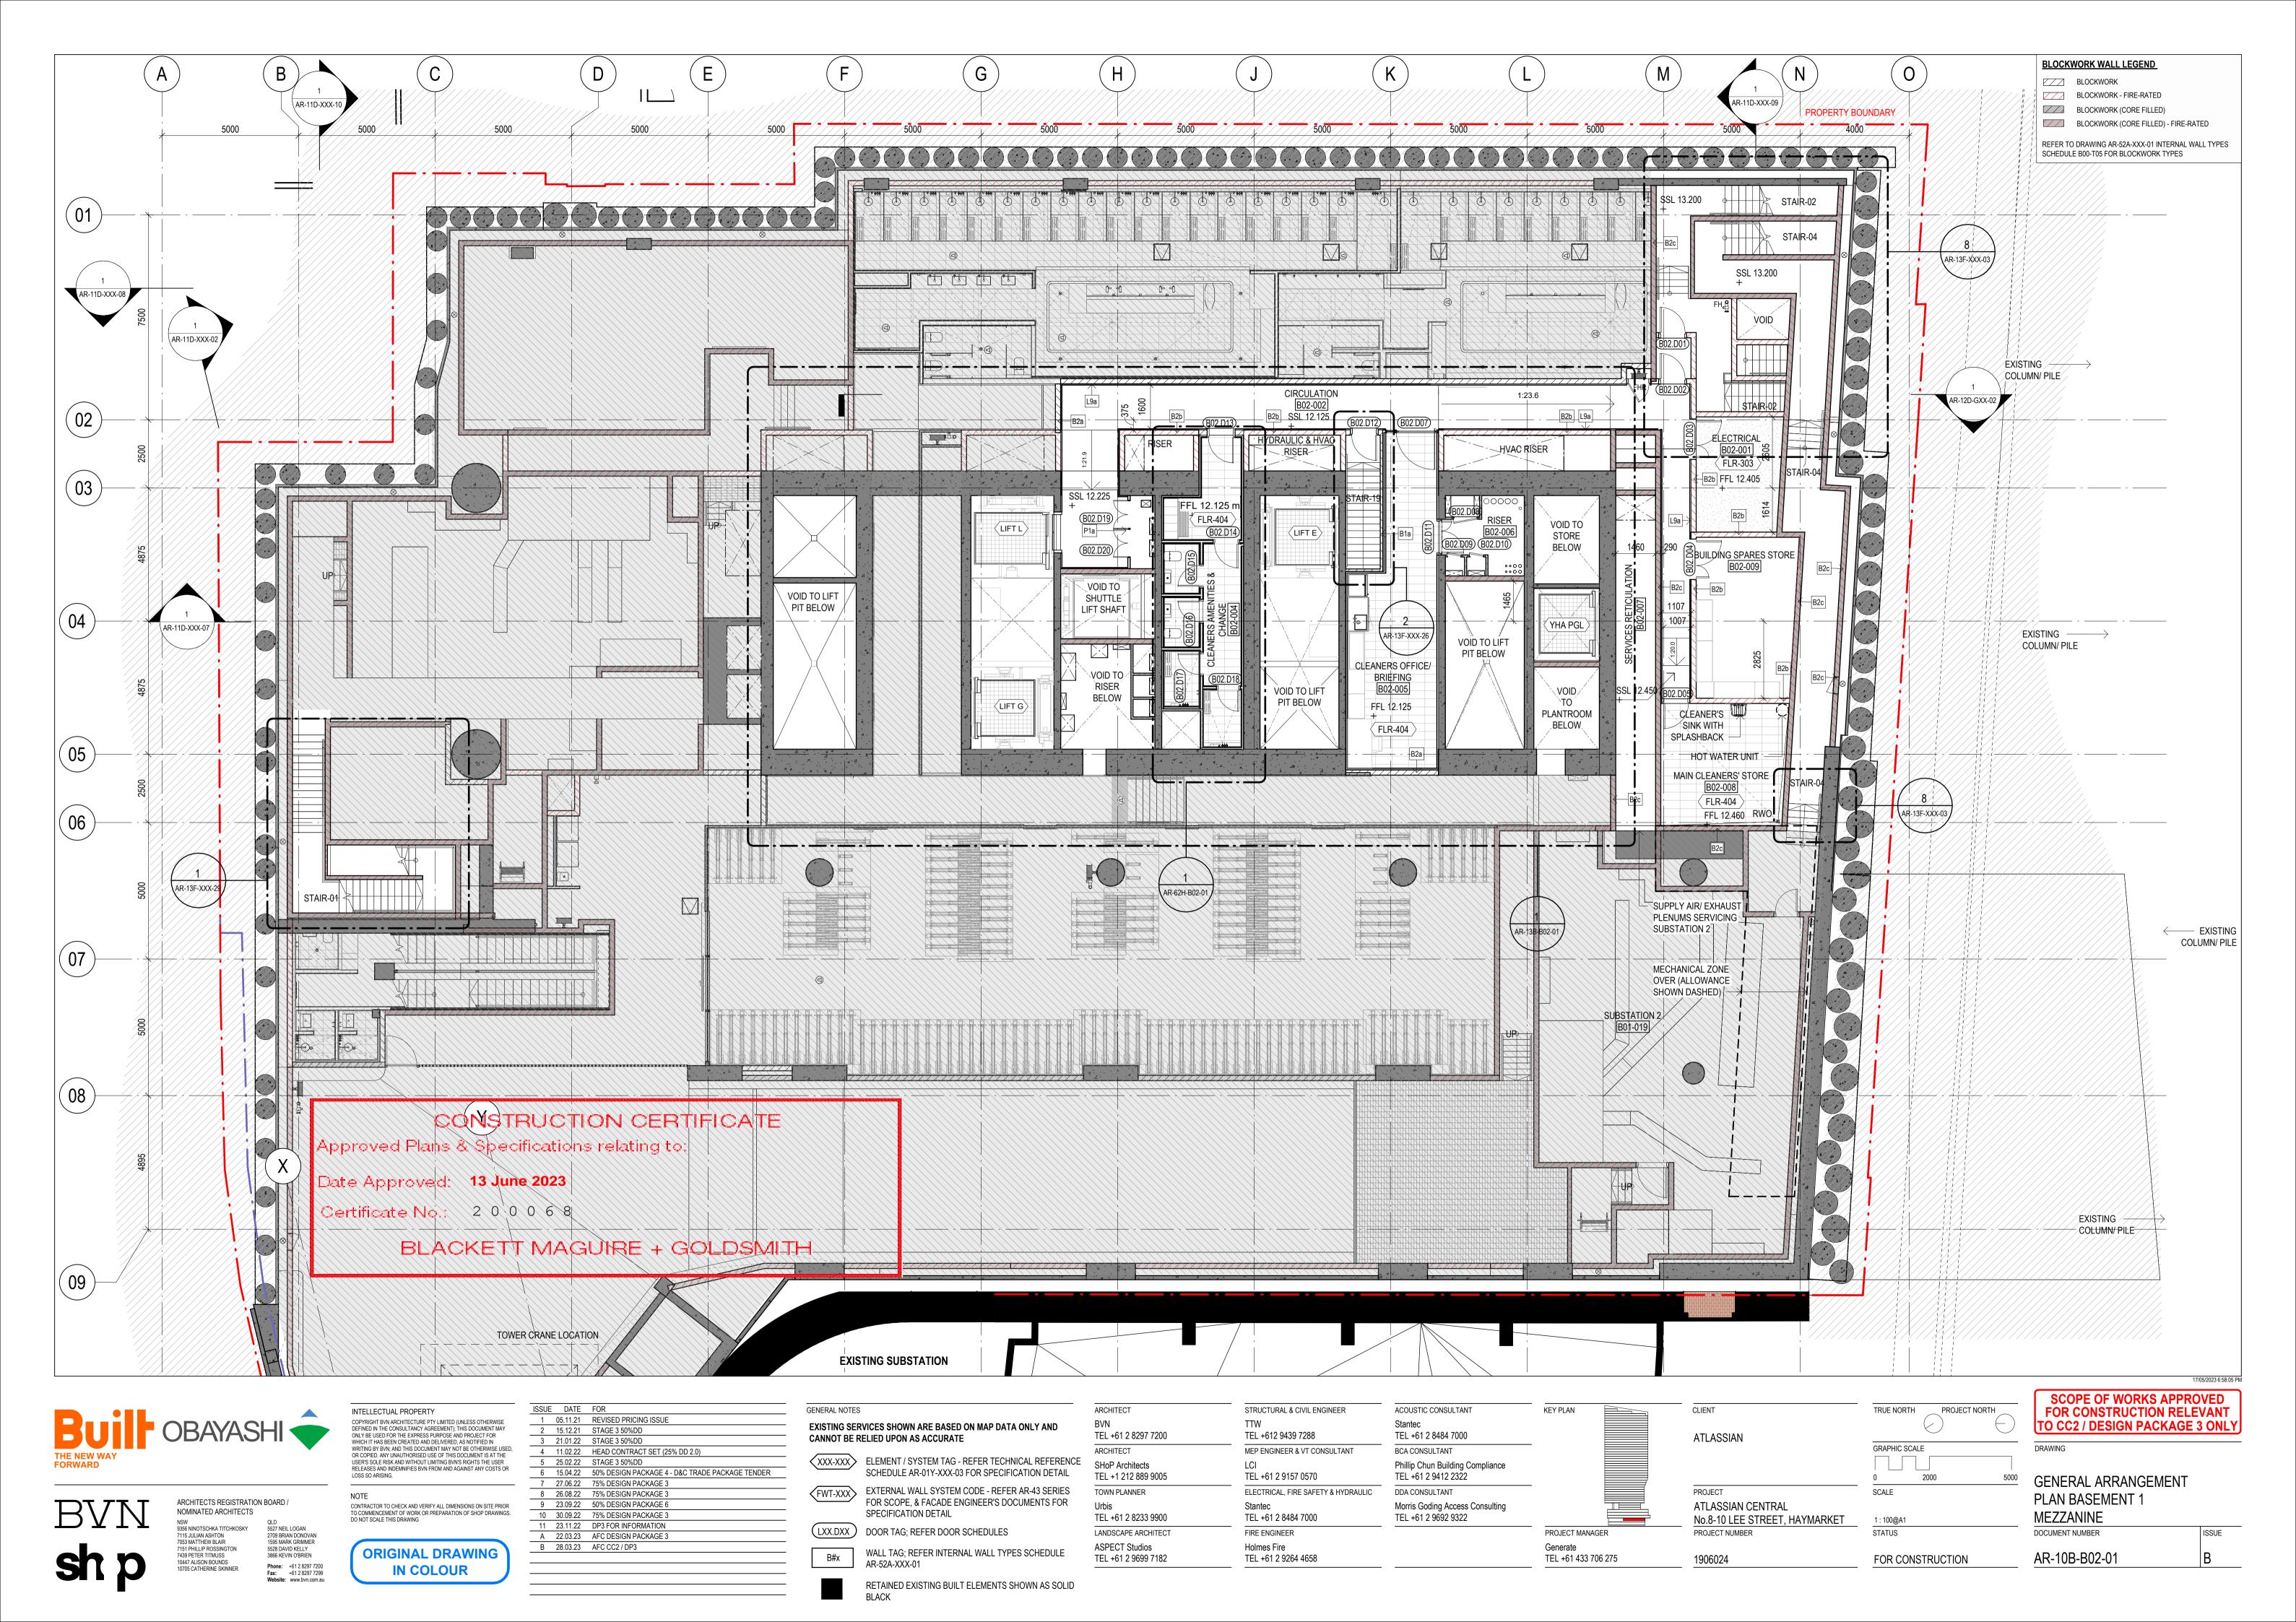


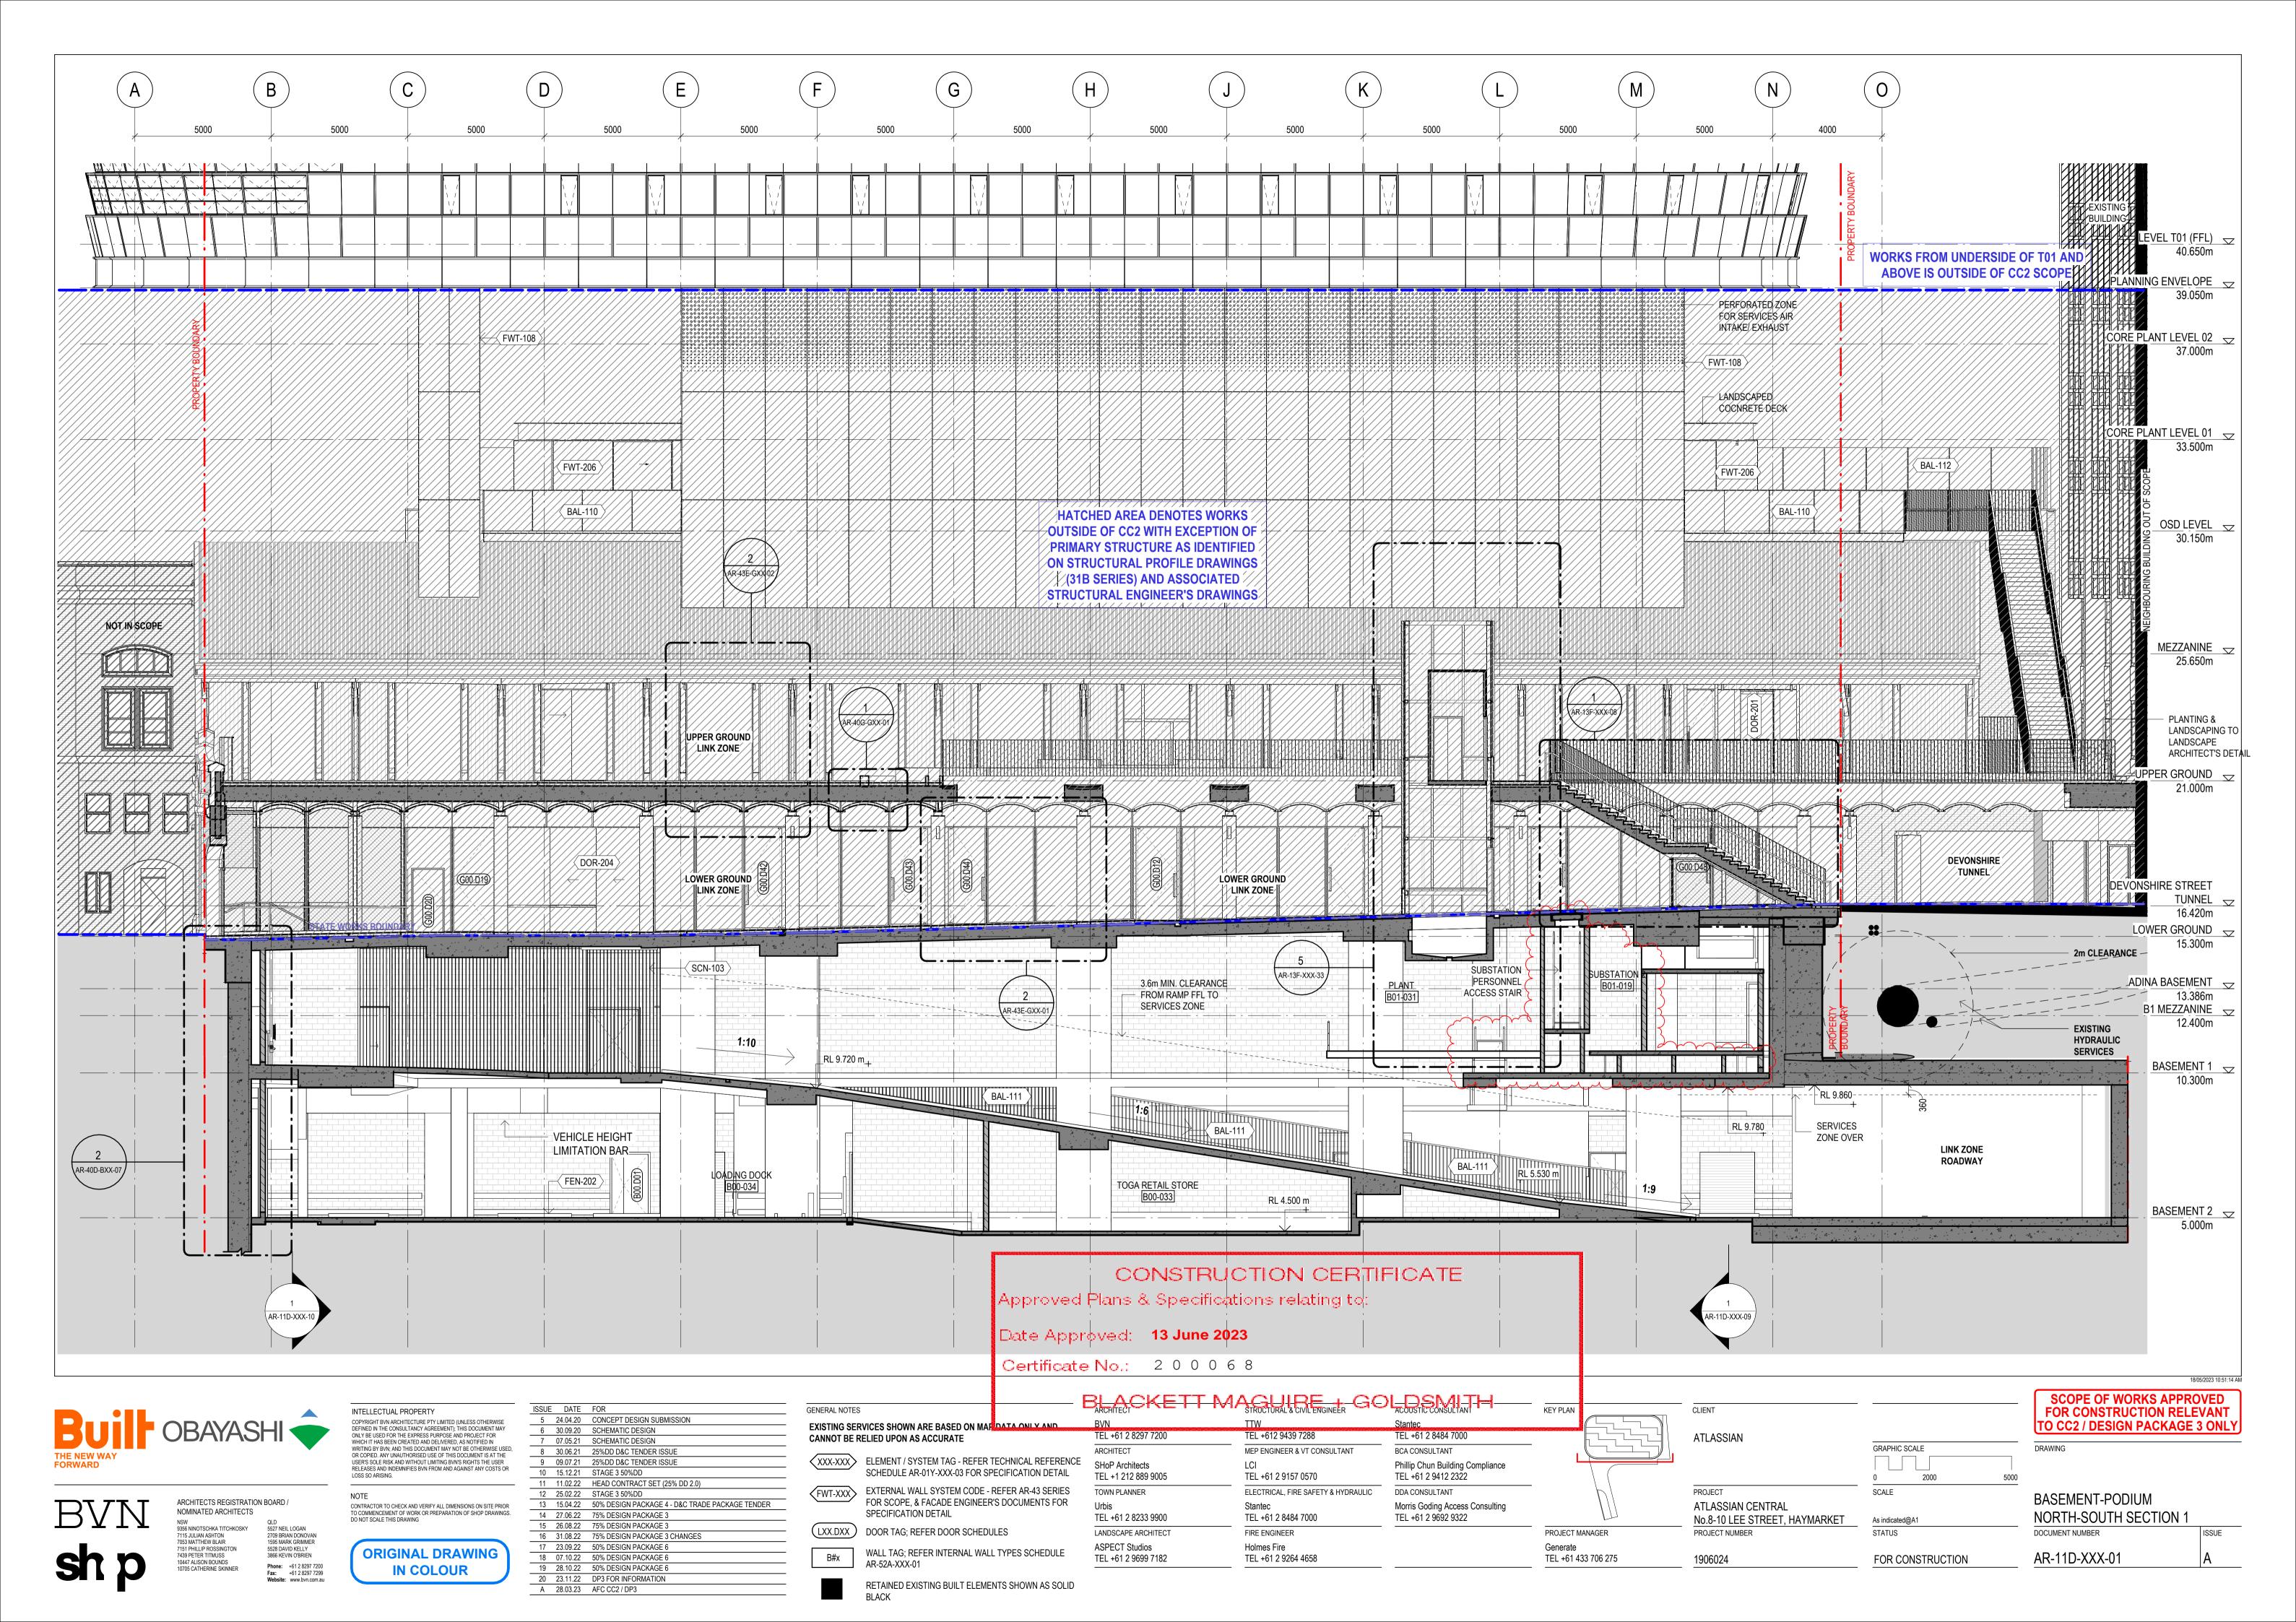

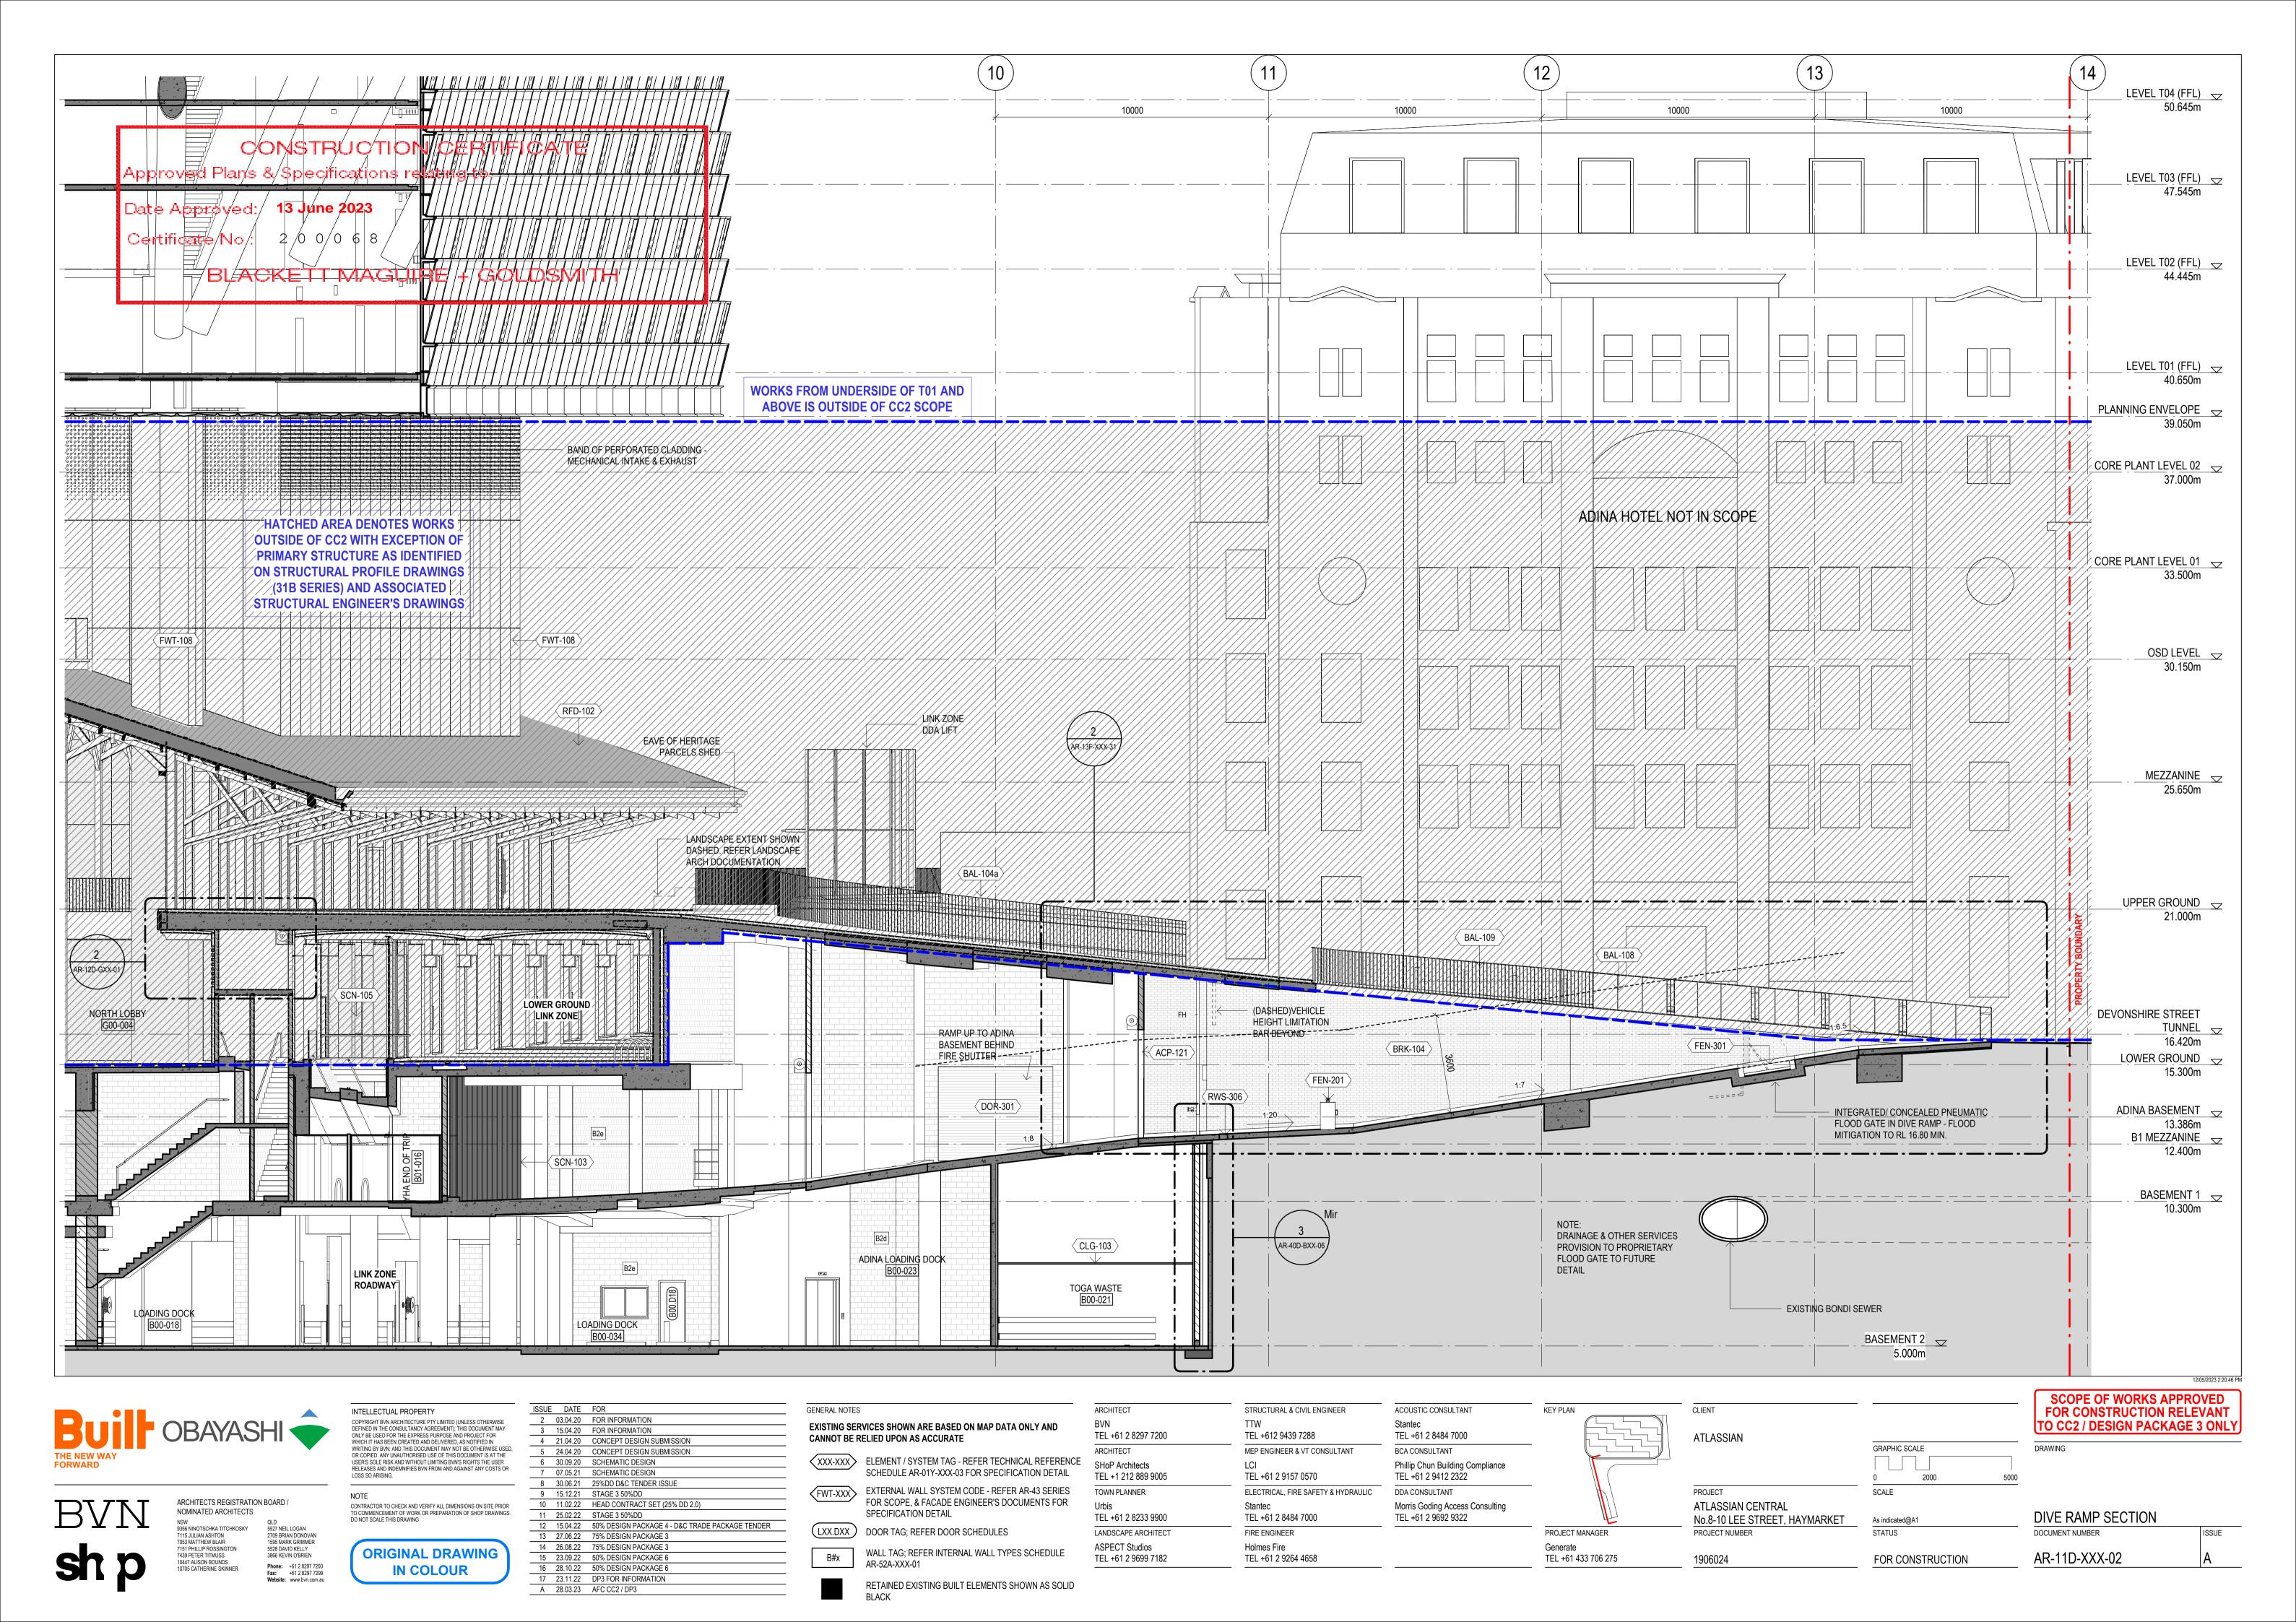

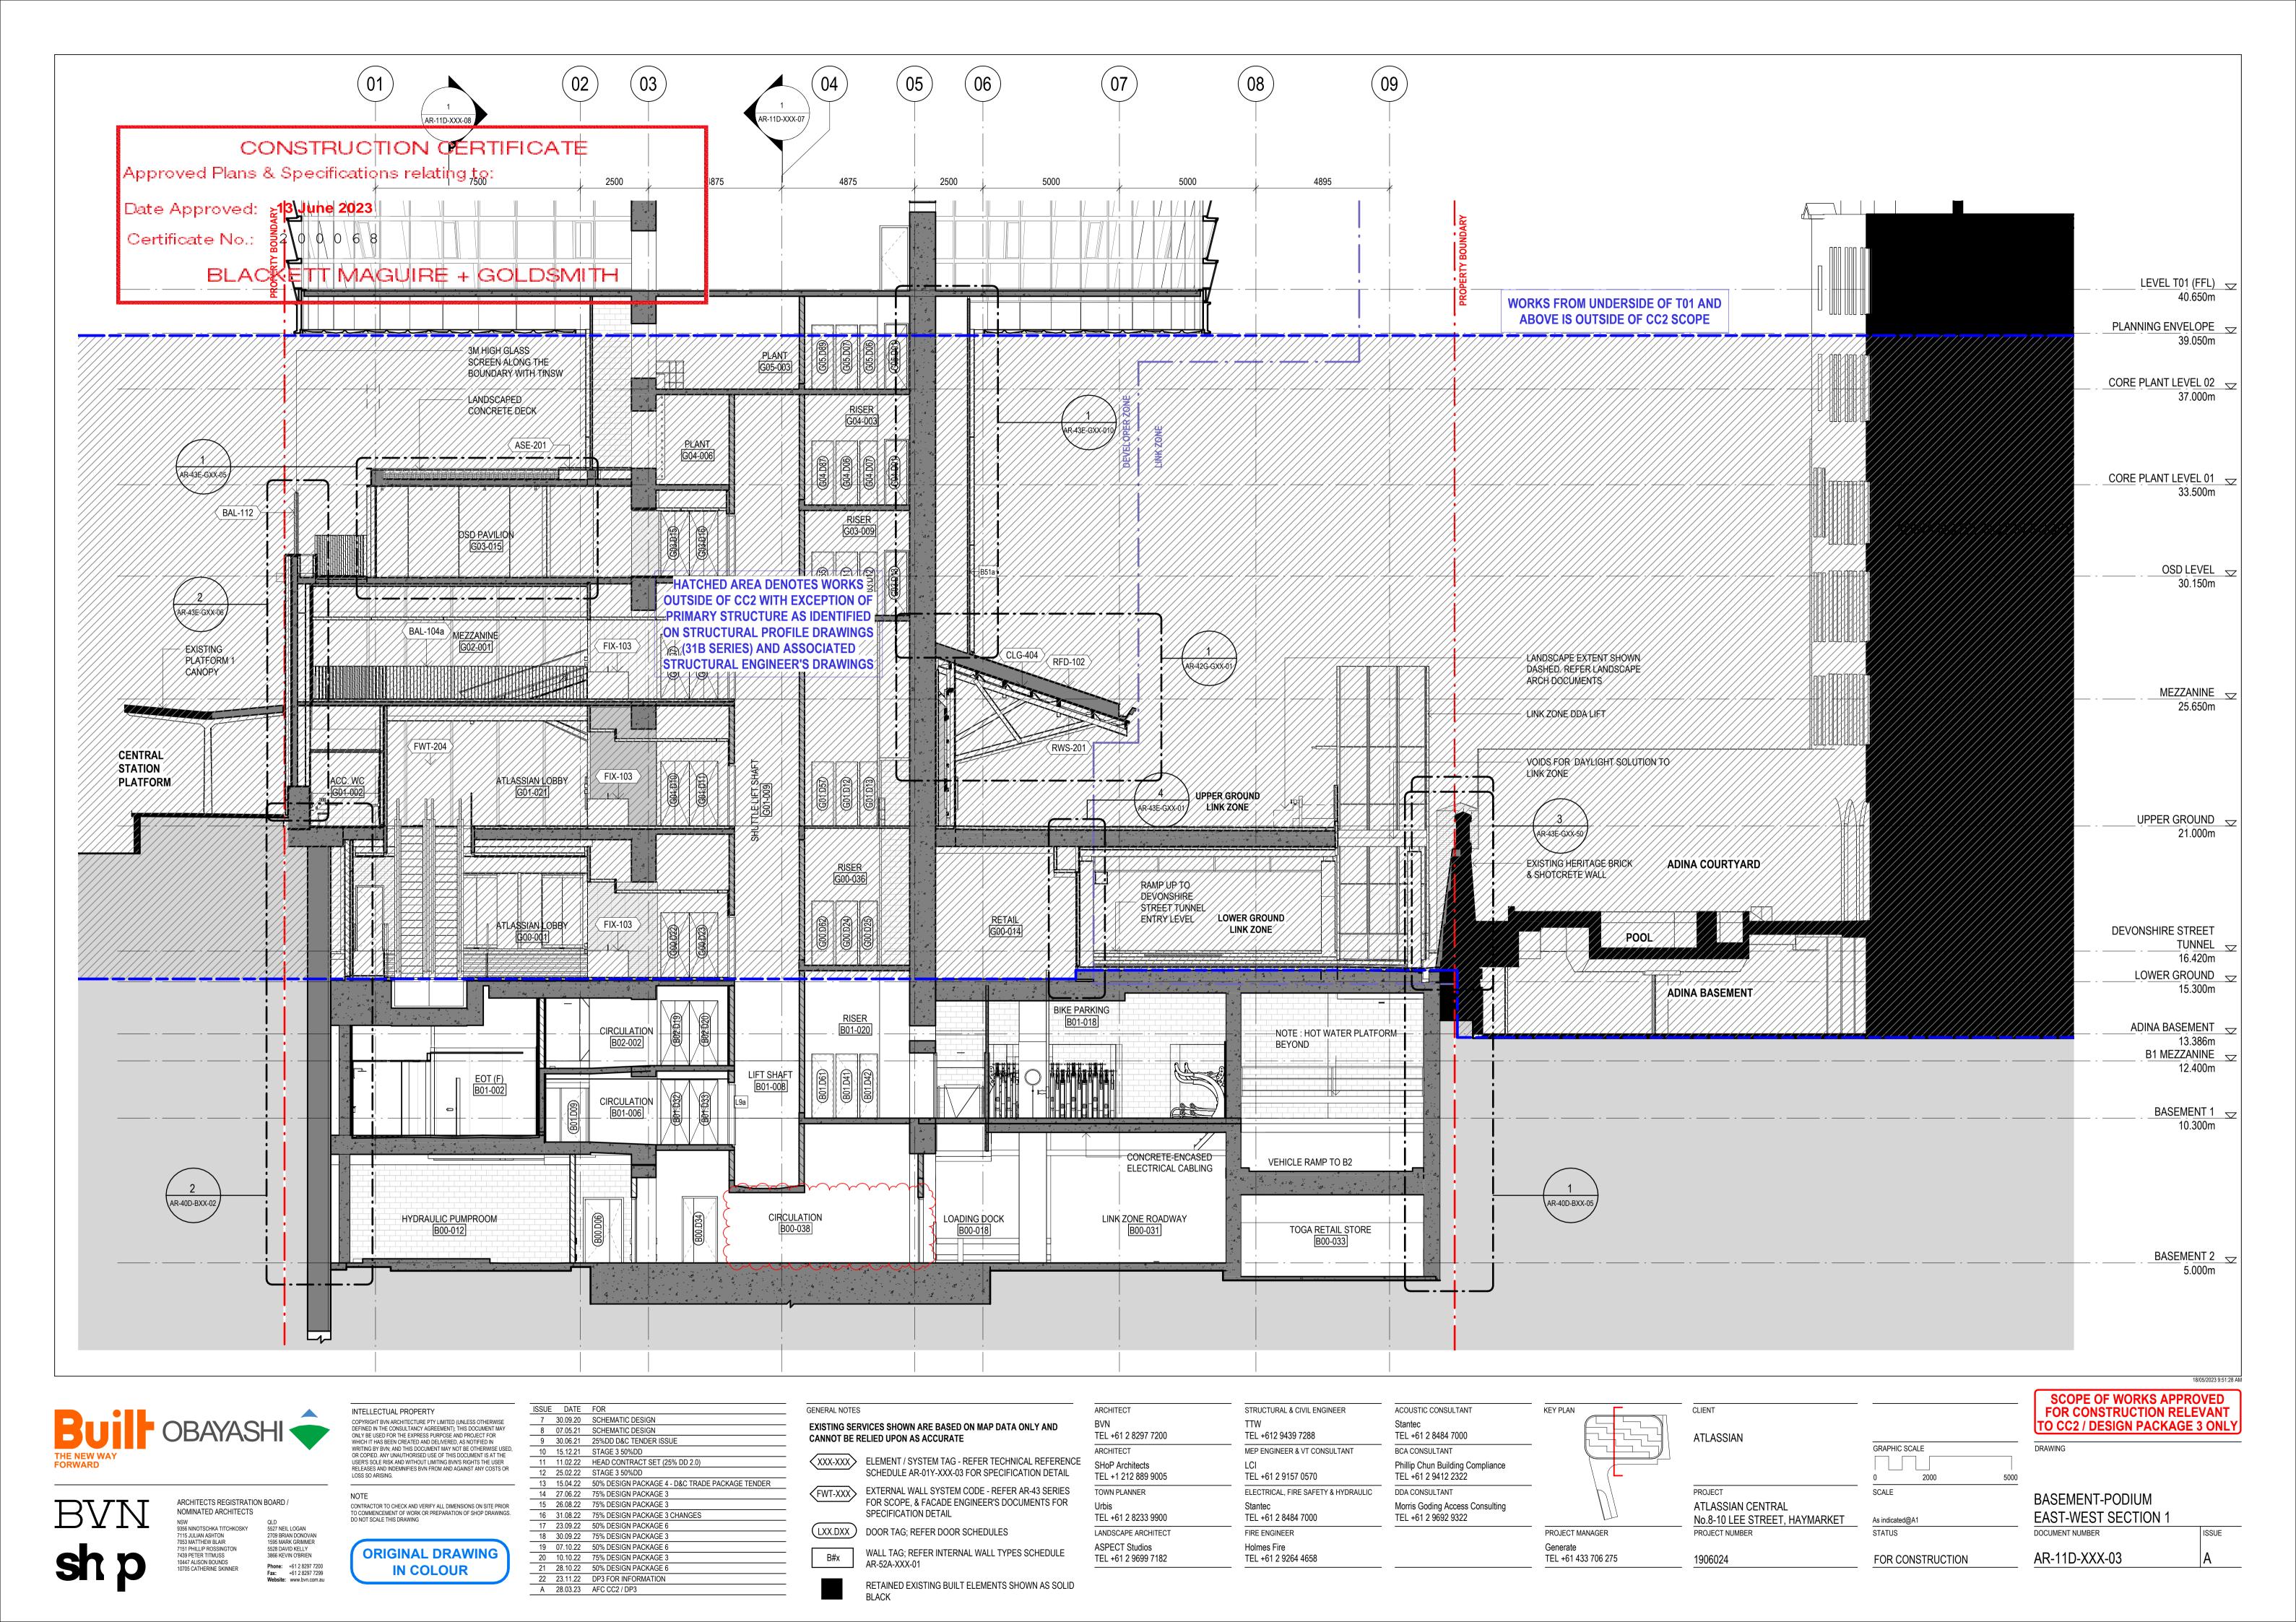

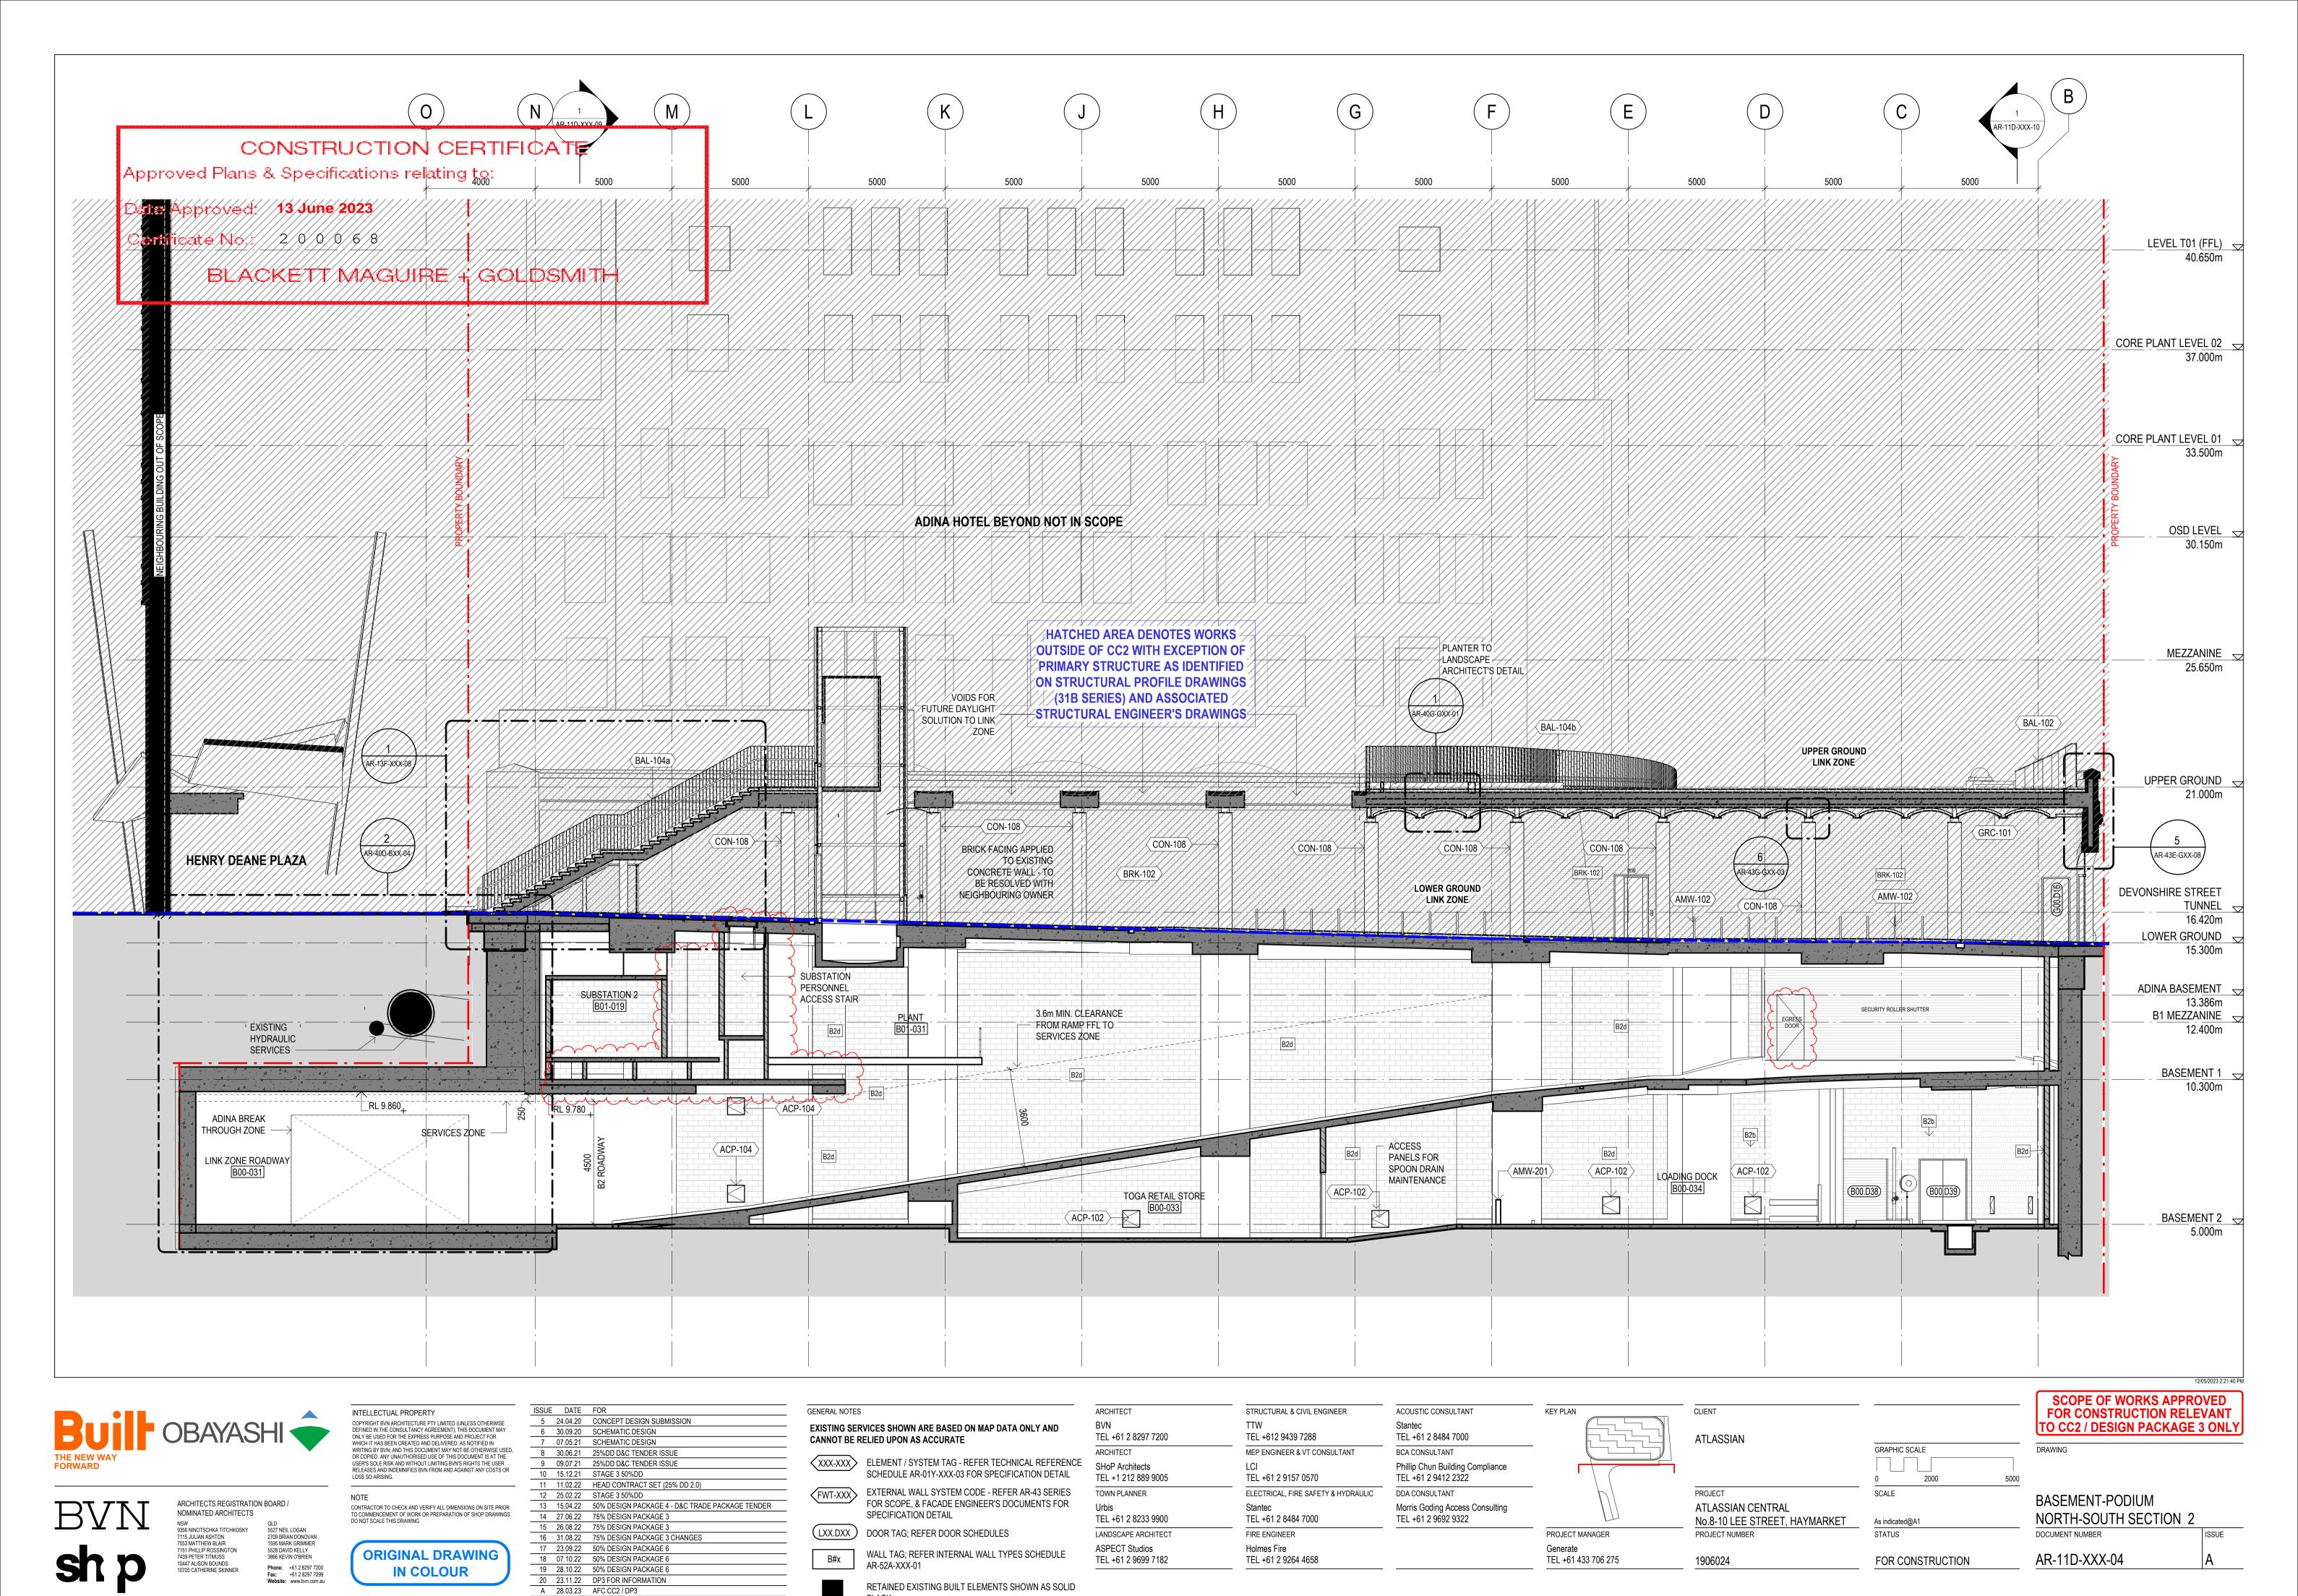

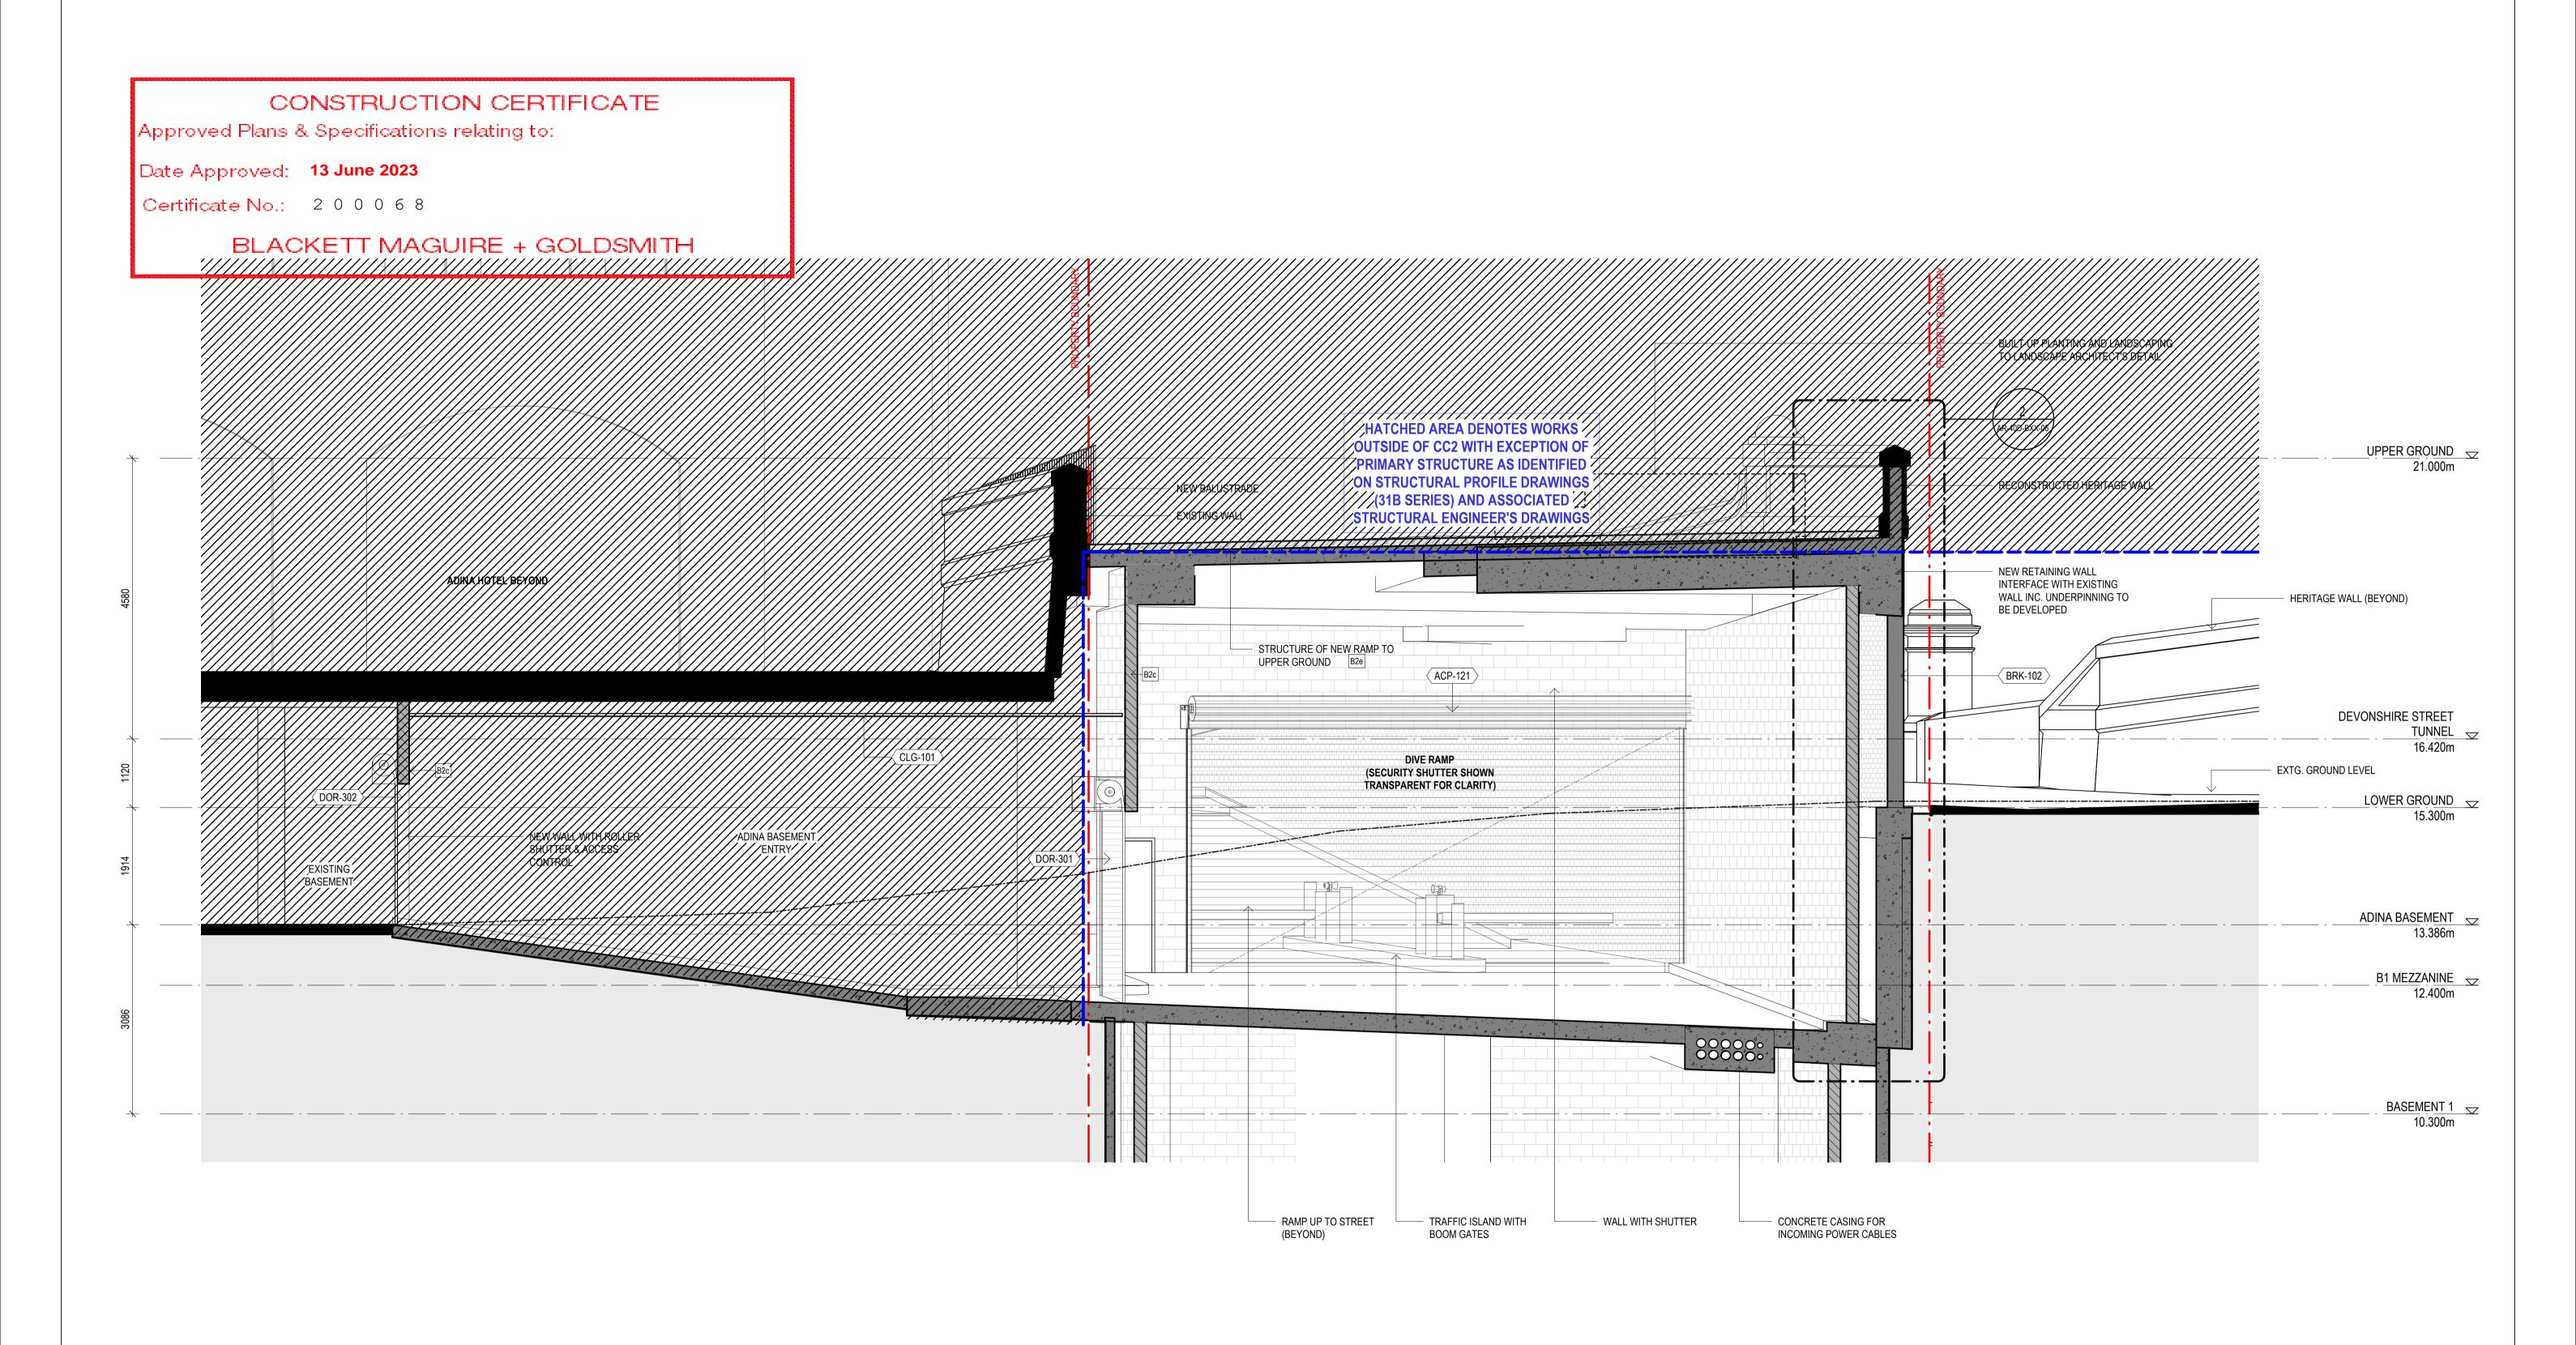



GLD 5527 NEIL LOGAN 2709 BRIAN DONOVAN 1595 MARK GRIMMER 5528 DAVID KELLY 3866 KEVIN O'BRIEN 7115 JULIAN ASHTON 7053 MATTHEW BLAIR 7151 PHILLIP ROSSINGTON 7439 PETER TITMUSS 10447 ALISON BOUNDS 10705 CATHERINE SKINNER Phone: +61 2 8297 7200 Fax: +61 2 8297 7299 Website: www.bvn.com.au INTELLECTUAL PROPERTY COPYRIGHT BVN ARCHITECTURE PTY LIMITED (UNLESS OTHERWISE DEFINED IN THE CONSULTANCY AGREEMENT); THIS DOCUMENT MAY ONLY BE USED FOR THE EXPRESS PURPOSE AND PROJECT FOR WHICH IT HAS BEEN CREATED AND DELIVERED, AS NOTIFIED IN WRITING BY BVN; AND THIS DOCUMENT MAY NOT BE OTHERWISE USED, OR COPIED. ANY UNAUTHORISED USE OF THIS DOCUMENT IS AT THE USER'S SOLE RISK AND WITHOUT LIMITING BVN'S RIGHTS THE USER RELEASES AND INDEMNIFIES BVN FROM AND AGAINST ANY COSTS OR

CONTRACTOR TO CHECK AND VERIFY ALL DIMENSIONS ON SITE PRIOR

ORIGINAL DRAWING IN COLOUR

ISSUE	DATE	FOR
1	15.04.20	FOR INFORMATION
2	21.04.20	CONCEPT DESIGN SUBMISSION
3	24.04.20	CONCEPT DESIGN SUBMISSION
4	30.09.20	SCHEMATIC DESIGN
5	07.05.21	SCHEMATIC DESIGN
6	30.06.21	25%DD D&C TENDER ISSUE
7	15.12.21	STAGE 3 50%DD
8	11.02.22	HEAD CONTRACT SET (25% DD 2.0)
9	25.02.22	STAGE 3 50%DD
10	15.04.22	50% DESIGN PACKAGE 4 - D&C TRADE PACKAGE TENDER
11	27.06.22	75% DESIGN PACKAGE 3
12	26.08.22	75% DESIGN PACKAGE 3
13	23.09.22	50% DESIGN PACKAGE 6
14	23.11.22	DP3 FOR INFORMATION
Α	28.03.23	AFC CC2 / DP3

GENERAL NOTES
EXISTING SERVICES SHOWN ARE BASED ON MAP DATA ONLY AND
CANNOT BE RELIED UPON AS ACCURATE

ELEMENT / SYSTEM TAG - REFER TECHNICAL REFERENCE SCHEDULE AR-01Y-XXX-03 FOR SPECIFICATION DETAIL FWT-XXX EXTERNAL WALL SYSTEM CODE - REFER AR-43 SERIES FOR SCOPE, & FACADE ENGINEER'S DOCUMENTS FOR



SPECIFICATION DETAIL

(LXX.DXX) DOOR TAG; REFER DOOR SCHEDULES WALL TAG; REFER INTERNAL WALL TYPES SCHEDULE AR-52A-XXX-01

TEL +61 2 8297 7200 SHoP Architects TEL +1 212 889 9005 TOWN PLANNER TEL +61 2 8233 9900 LANDSCAPE ARCHITECT ASPECT Studios TEL +61 2 9699 7182

ARCHITECT


STRUCTURAL & CIVIL ENGINEER TEL +612 9439 7288 MEP ENGINEER & VT CONSULTANT TEL +61 2 9157 0570 ELECTRICAL, FIRE SAFETY & HYDRAULIC TEL +61 2 8484 7000 FIRE ENGINEER

Holmes Fire

TEL +61 2 9264 4658

ACOUSTIC CONSULTANT KEY PLAN TEL +61 2 8484 7000 BCA CONSULTANT Phillip Chun Building Compliance TEL +61 2 9412 2322 DDA CONSULTANT Morris Goding Access Consulting TEL +61 2 9692 9322 PROJECT MANAGER Generate

TEL +61 433 706 275

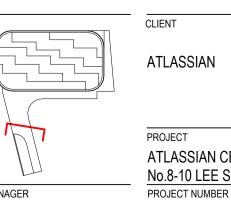


1906024

ATLASSIAN GRAPHIC SCALE SCALE ATLASSIAN CENTRAL No.8-10 LEE STREET, HAYMARKET As indicated@A1 STATUS

FOR CONSTRUCTION

SCOPE OF WORKS APPROVED FOR CONSTRUCTION RELEVANT TO CC2 / DESIGN PACKAGE 3 ONLY DRAWING ADINA BASEMENT ENTRY SECTION DOCUMENT NUMBER ISSUE

AR-11D-XXX-05

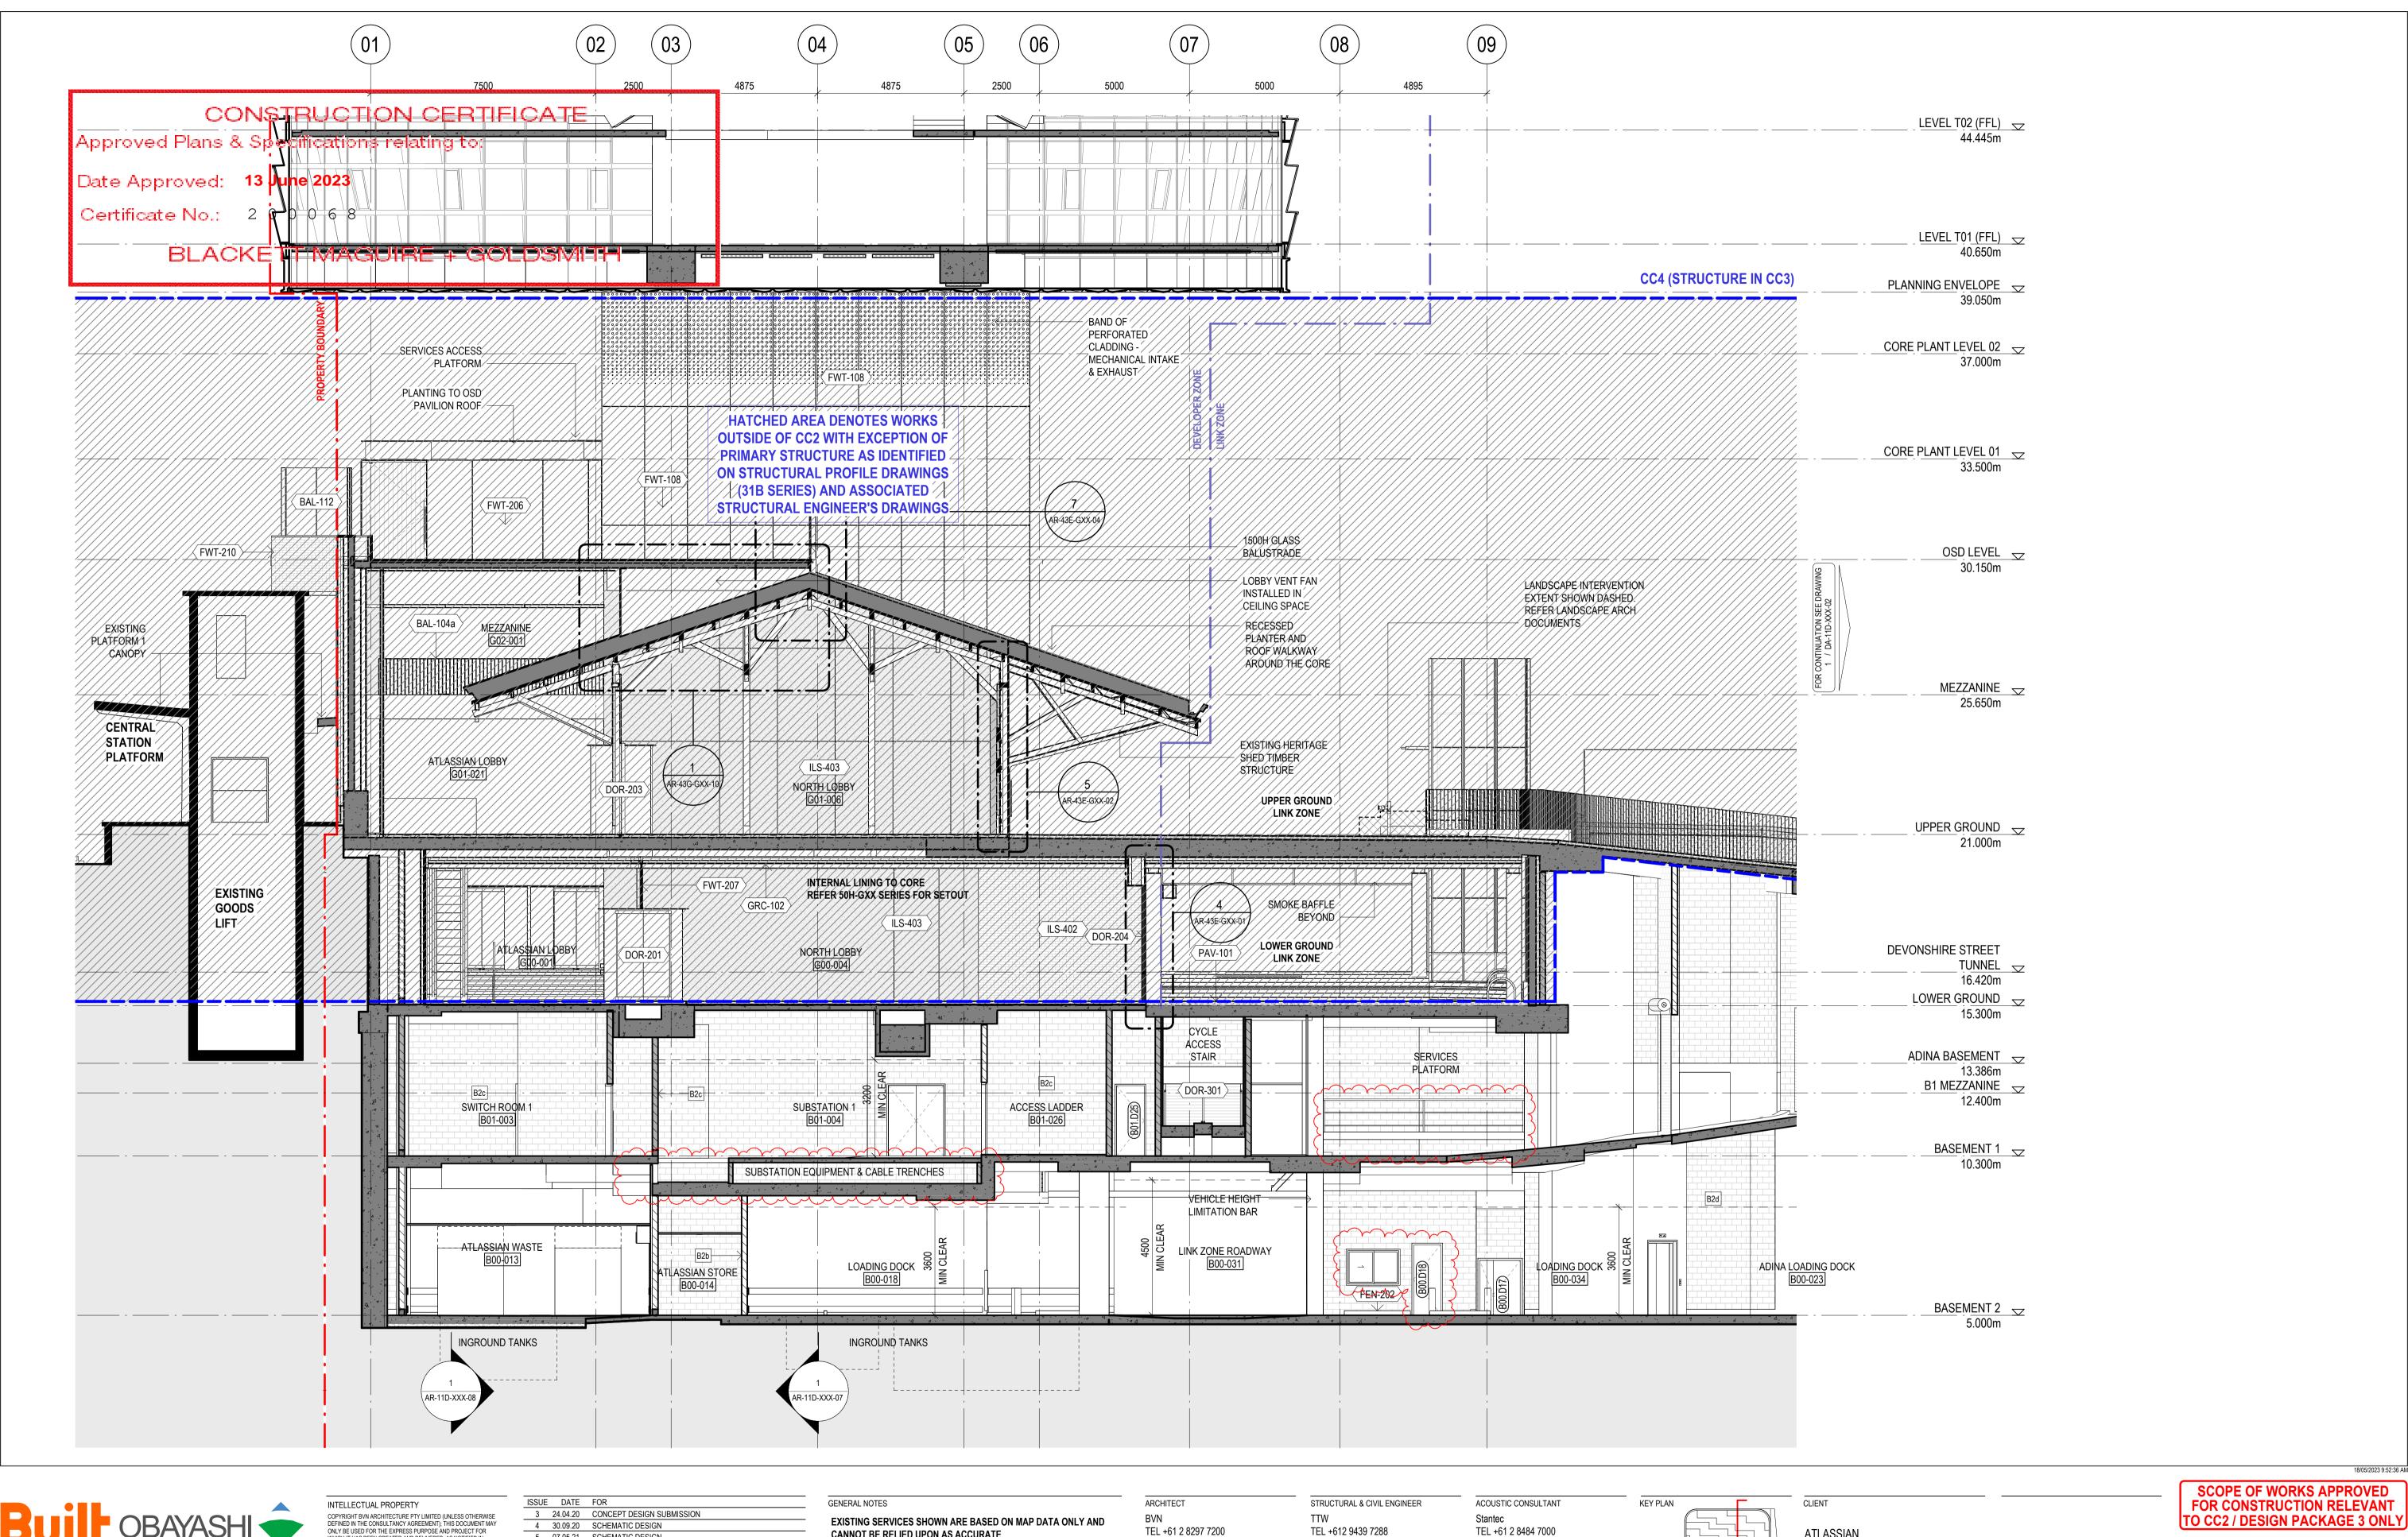



QLD 5527 NEIL LOGAN 2709 BRIAN DONOVAN 1595 MARK GRIMMER 5528 DAVID KELLY 3866 KEVIN O'BRIEN 7115 JULIAN ASHTON 7053 MATTHEW BLAIR 7151 PHILLIP ROSSINGTON 7439 PETER TITMUSS 10447 ALISON BOUNDS 10705 CATHERINE SKINNER Phone: +61 2 8297 7200 Fax: +61 2 8297 7299 Website: www.bvn.com.au COPYRIGHT BVN ARCHITECTURE PTY LIMITED (UNLESS OTHERWISE DEFINED IN THE CONSULTANCY AGREEMENT); THIS DOCUMENT MAY ONLY BE USED FOR THE EXPRESS PURPOSE AND PROJECT FOR WHICH IT HAS BEEN CREATED AND DELIVERED, AS NOTIFIED IN WRITING BY BVN; AND THIS DOCUMENT MAY NOT BE OTHERWISE USED, OR COPIED. ANY UNAUTHORISED USE OF THIS DOCUMENT IS AT THE USER'S SOLE RISK AND WITHOUT LIMITING BVN'S RIGHTS THE USER RELEASES AND INDEMNIFIES BVN FROM AND AGAINST ANY COSTS OR


CONTRACTOR TO CHECK AND VERIFY ALL DIMENSIONS ON SITE PRIOR

ORIGINAL DRAWING IN COLOUR

SUE	DATE	FOR
3	24.04.20	CONCEPT DESIGN SUBMISSION
4	30.09.20	SCHEMATIC DESIGN
5	07.05.21	SCHEMATIC DESIGN
6	30.06.21	25%DD D&C TENDER ISSUE
7	15.12.21	STAGE 3 50%DD
8	21.01.22	STAGE 3 50%DD
9	11.02.22	HEAD CONTRACT SET (25% DD 2.0)
0	25.02.22	STAGE 3 50%DD
1	15.04.22	50% DESIGN PACKAGE 4 - D&C TRADE PACKAGE TENDER
2	27.06.22	75% DESIGN PACKAGE 3
3	26.08.22	75% DESIGN PACKAGE 3
4	23.09.22	50% DESIGN PACKAGE 6
5	30.09.22	75% DESIGN PACKAGE 3
6	07.10.22	50% DESIGN PACKAGE 6
7	28.10.22	50% DESIGN PACKAGE 6
8	23.11.22	DP3 FOR INFORMATION
4	28.03.23	AFC CC2 / DP3

CANNOT BE RELIED UPON AS ACCURATE

 ELEMENT / SYSTEM TAG - REFER TECHNICAL REFERENCE SCHEDULE AR-01Y-XXX-03 FOR SPECIFICATION DETAIL FWT-XXX EXTERNAL WALL SYSTEM CODE - REFER AR-43 SERIES FOR SCOPE, & FACADE ENGINEER'S DOCUMENTS FOR SPECIFICATION DETAIL



WALL TAG; REFER INTERNAL WALL TYPES SCHEDULE AR-52A-XXX-01

TOWN PLANNER TEL +61 2 8233 9900 LANDSCAPE ARCHITECT ASPECT Studios TEL +61 2 9699 7182

FIRE ENGINEER

TEL +61 2 9264 4658

Holmes Fire

ARCHITECT

SHoP Architects

TEL +1 212 889 9005

TEL +61 2 8484 7000 MEP ENGINEER & VT CONSULTANT BCA CONSULTANT Phillip Chun Building Compliance TEL +61 2 9157 0570 TEL +61 2 9412 2322 ELECTRICAL, FIRE SAFETY & HYDRAULIC DDA CONSULTANT Morris Goding Access Consulting TEL +61 2 9692 9322 TEL +61 2 8484 7000

PROJECT MANAGER Generate TEL +61 433 706 275 1906024


ATLASSIAN GRAPHIC SCALE PROJECT SCALE ATLASSIAN CENTRAL No.8-10 LEE STREET, HAYMARKET As indicated@A1 STATUS PROJECT NUMBER

FOR CONSTRUCTION

DRAWING

AR-11D-XXX-06

BASEMENT-PODIUM EAST-WEST SECTION 2 DOCUMENT NUMBER

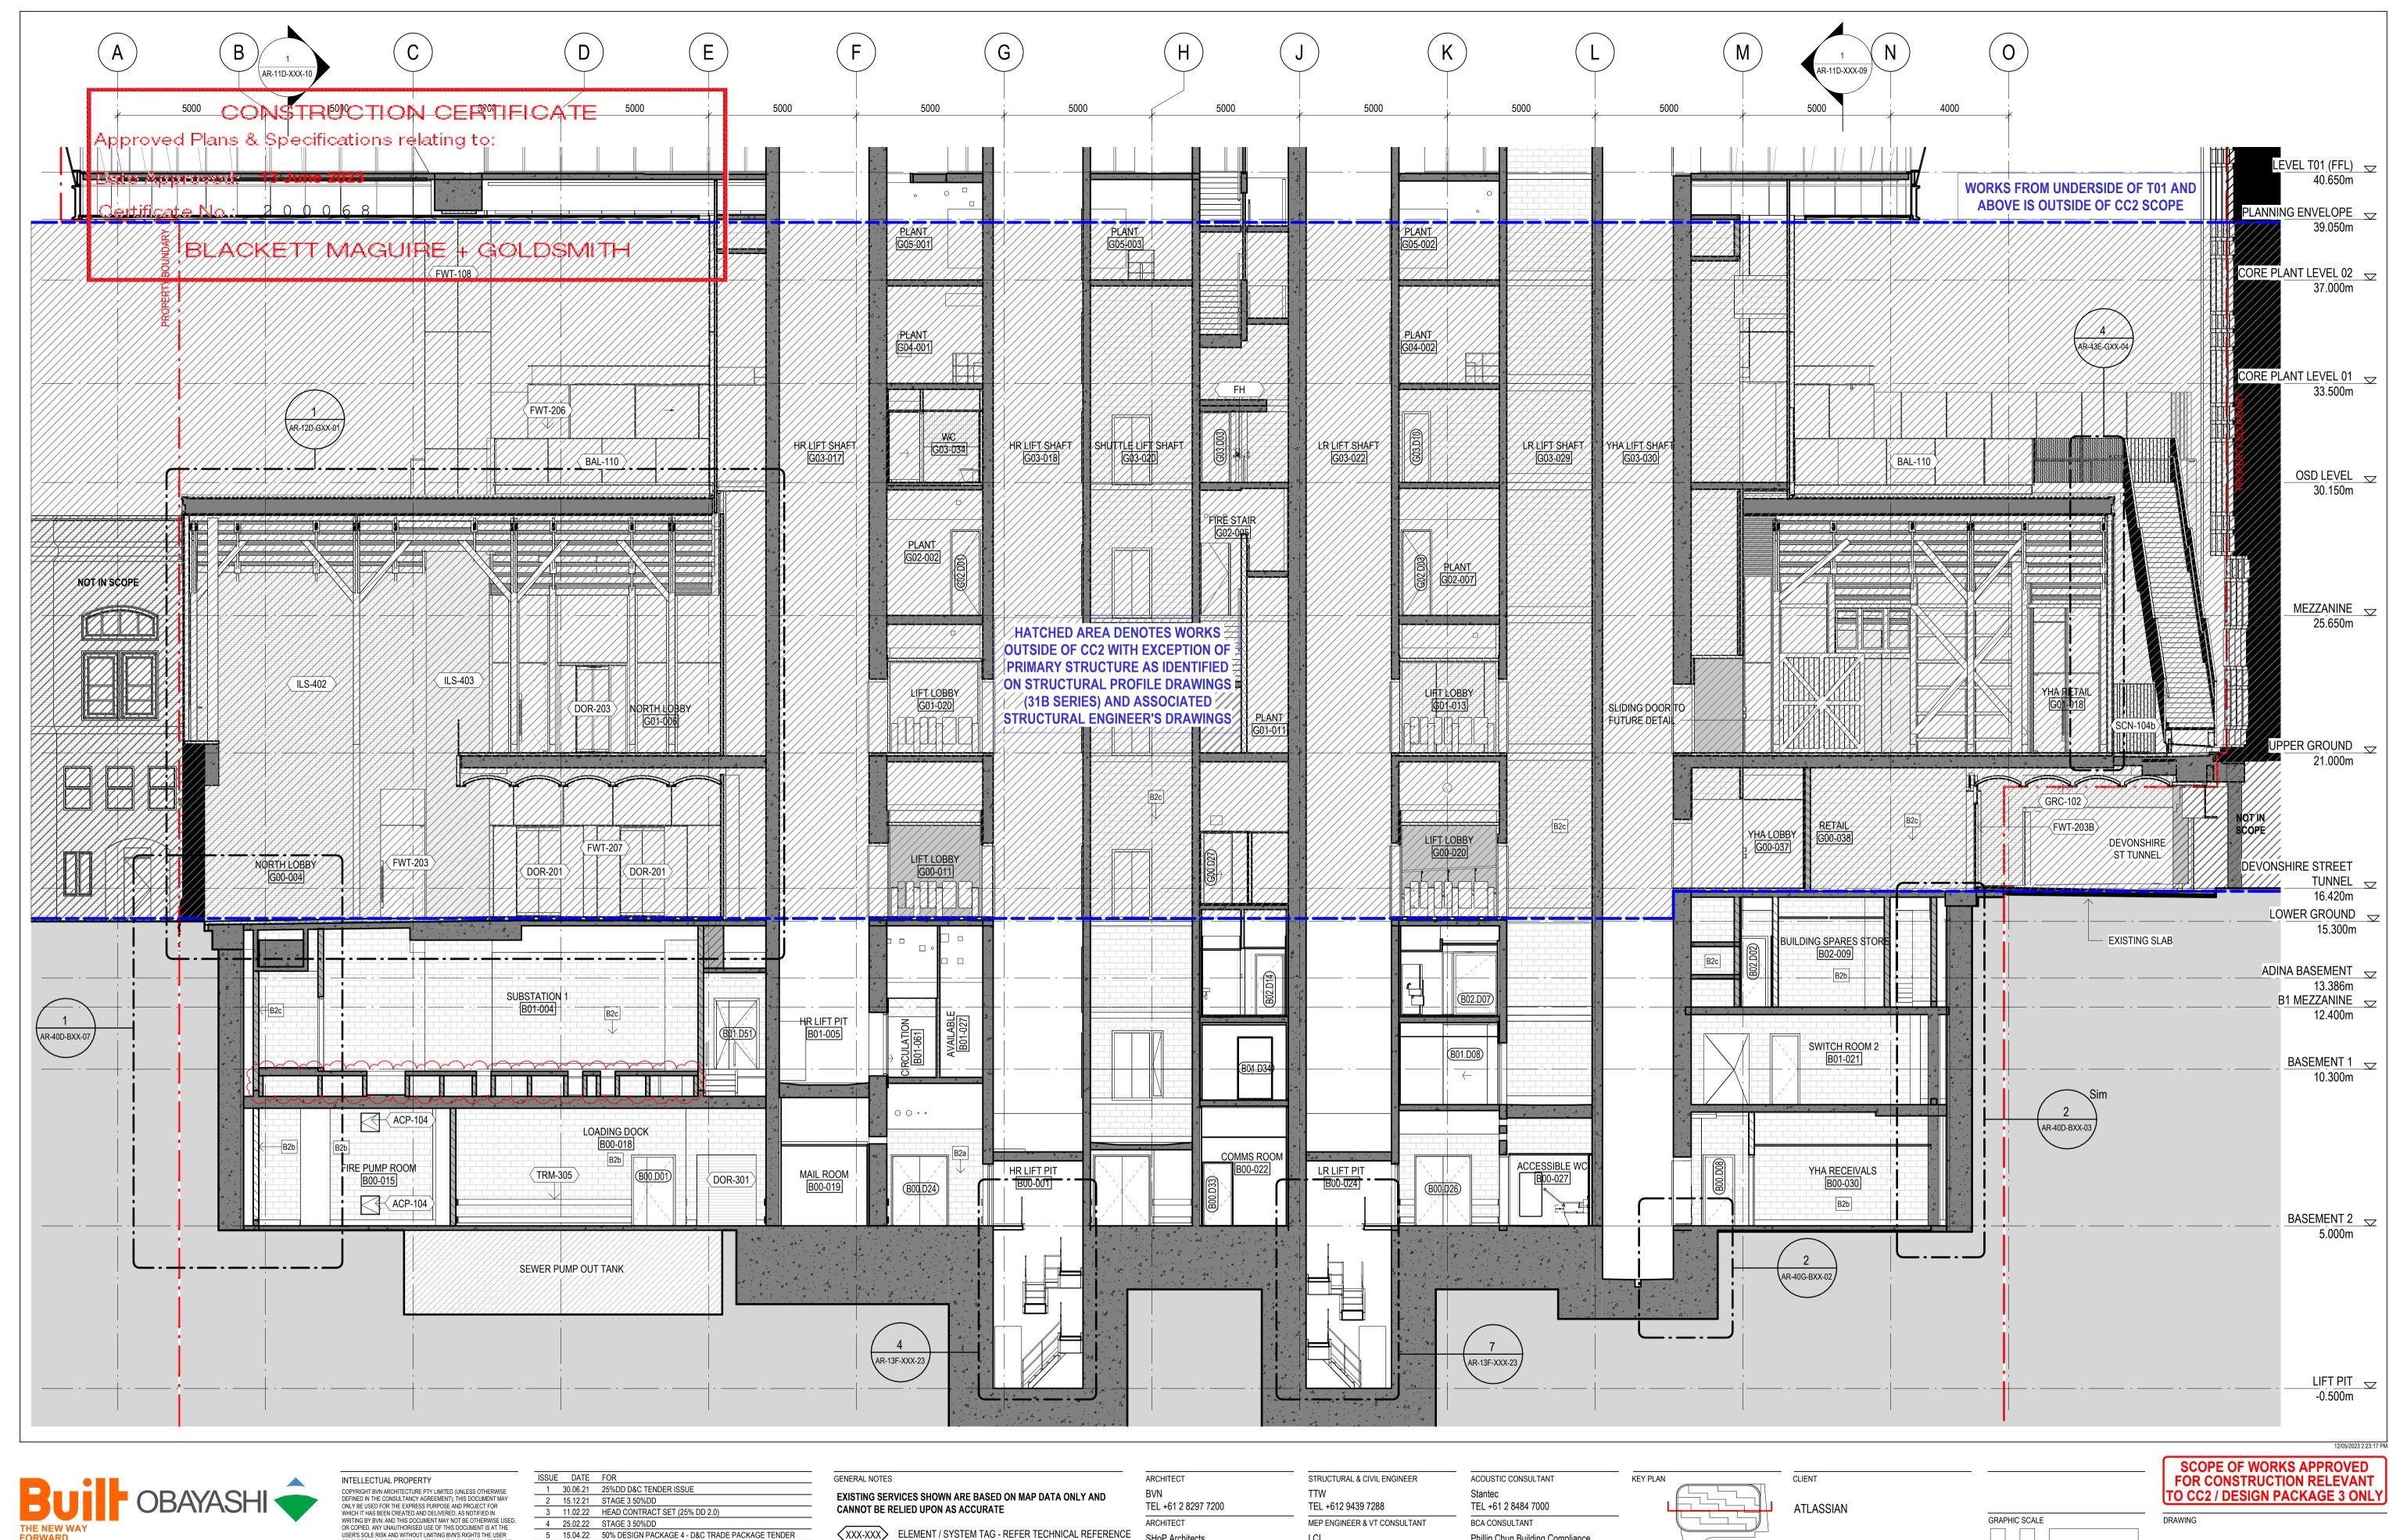



QLD 5527 NEIL LOGAN 2709 BRIAN DONOVAN 1595 MARK GRIMMER 5528 DAVID KELLY 3866 KEVIN O'BRIEN 7115 JULIAN ASHTON 7053 MATTHEW BLAIR 7151 PHILLIP ROSSINGTON 7439 PETER TITMUSS 10447 ALISON BOUNDS 10705 CATHERINE SKINNER Phone: +61 2 8297 7200 Fax: +61 2 8297 7299 Website: www.bvn.com.au

ORIGINAL DRAWING

CONTRACTOR TO CHECK AND VERIFY ALL DIMENSIONS ON SITE PRIOR

IN COLOUR

WRITING BY BVN; AND THIS DOCUMENT MAY NOT BE OTHERWISE USED, OR COPIED. ANY UNAUTHORISED USE OF THIS DOCUMENT IS AT THE USER'S SOLE RISK AND WITHOUT LIMITING BVN'S RIGHTS THE USER RELEASES AND INDEMNIFIES BVN FROM AND AGAINST ANY COSTS OR LOSS SO ARISING. A 28.03.23 AFC CC2 / DP3

4 25.02.22 STAGE 3 50%DD 5 15.04.22 50% DESIGN PACKAGE 4 - D&C TRADE PACKAGE TENDER 6 27.06.22 75% DESIGN PACKAGE 3 7 26.08.22 75% DESIGN PACKAGE 3 8 23.09.22 50% DESIGN PACKAGE 6 9 07.10.22 50% DESIGN PACKAGE 6 10 23.11.22 DP3 FOR INFORMATION

SCHEDULE AR-01Y-XXX-03 FOR SPECIFICATION DETAIL FWT-XXX EXTERNAL WALL SYSTEM CODE - REFER AR-43 SERIES FOR SCOPE, & FACADE ENGINEER'S DOCUMENTS FOR SPECIFICATION DETAIL

LXX.DXX) DOOR TAG; REFER DOOR SCHEDULES AR-52A-XXX-01

WALL TAG; REFER INTERNAL WALL TYPES SCHEDULE RETAINED EXISTING BUILT ELEMENTS SHOWN AS SOLID SHoP Architects TEL +1 212 889 9005 TEL +61 2 9157 0570 TOWN PLANNER ELECTRICAL, FIRE SAFETY & HYDRAULIC Stantec

TEL +61 2 8484 7000

TEL +61 2 9264 4658

FIRE ENGINEER

Holmes Fire

TEL +61 2 8233 9900 LANDSCAPE ARCHITECT ASPECT Studios TEL +61 2 9699 7182

Phillip Chun Building Compliance TEL +61 2 9412 2322 DDA CONSULTANT Morris Goding Access Consulting TEL +61 2 9692 9322

PROJECT MANAGER Generate TEL +61 433 706 275

PROJECT ATLASSIAN CENTRAL No.8-10 LEE STREET, HAYMARKET PROJECT NUMBER

1906024


2000 SCALE


As indicated@A1

STATUS

BASEMENT-PODIUM NORTH-SOUTH SECTION 3 DOCUMENT NUMBER

AR-11D-XXX-07 FOR CONSTRUCTION

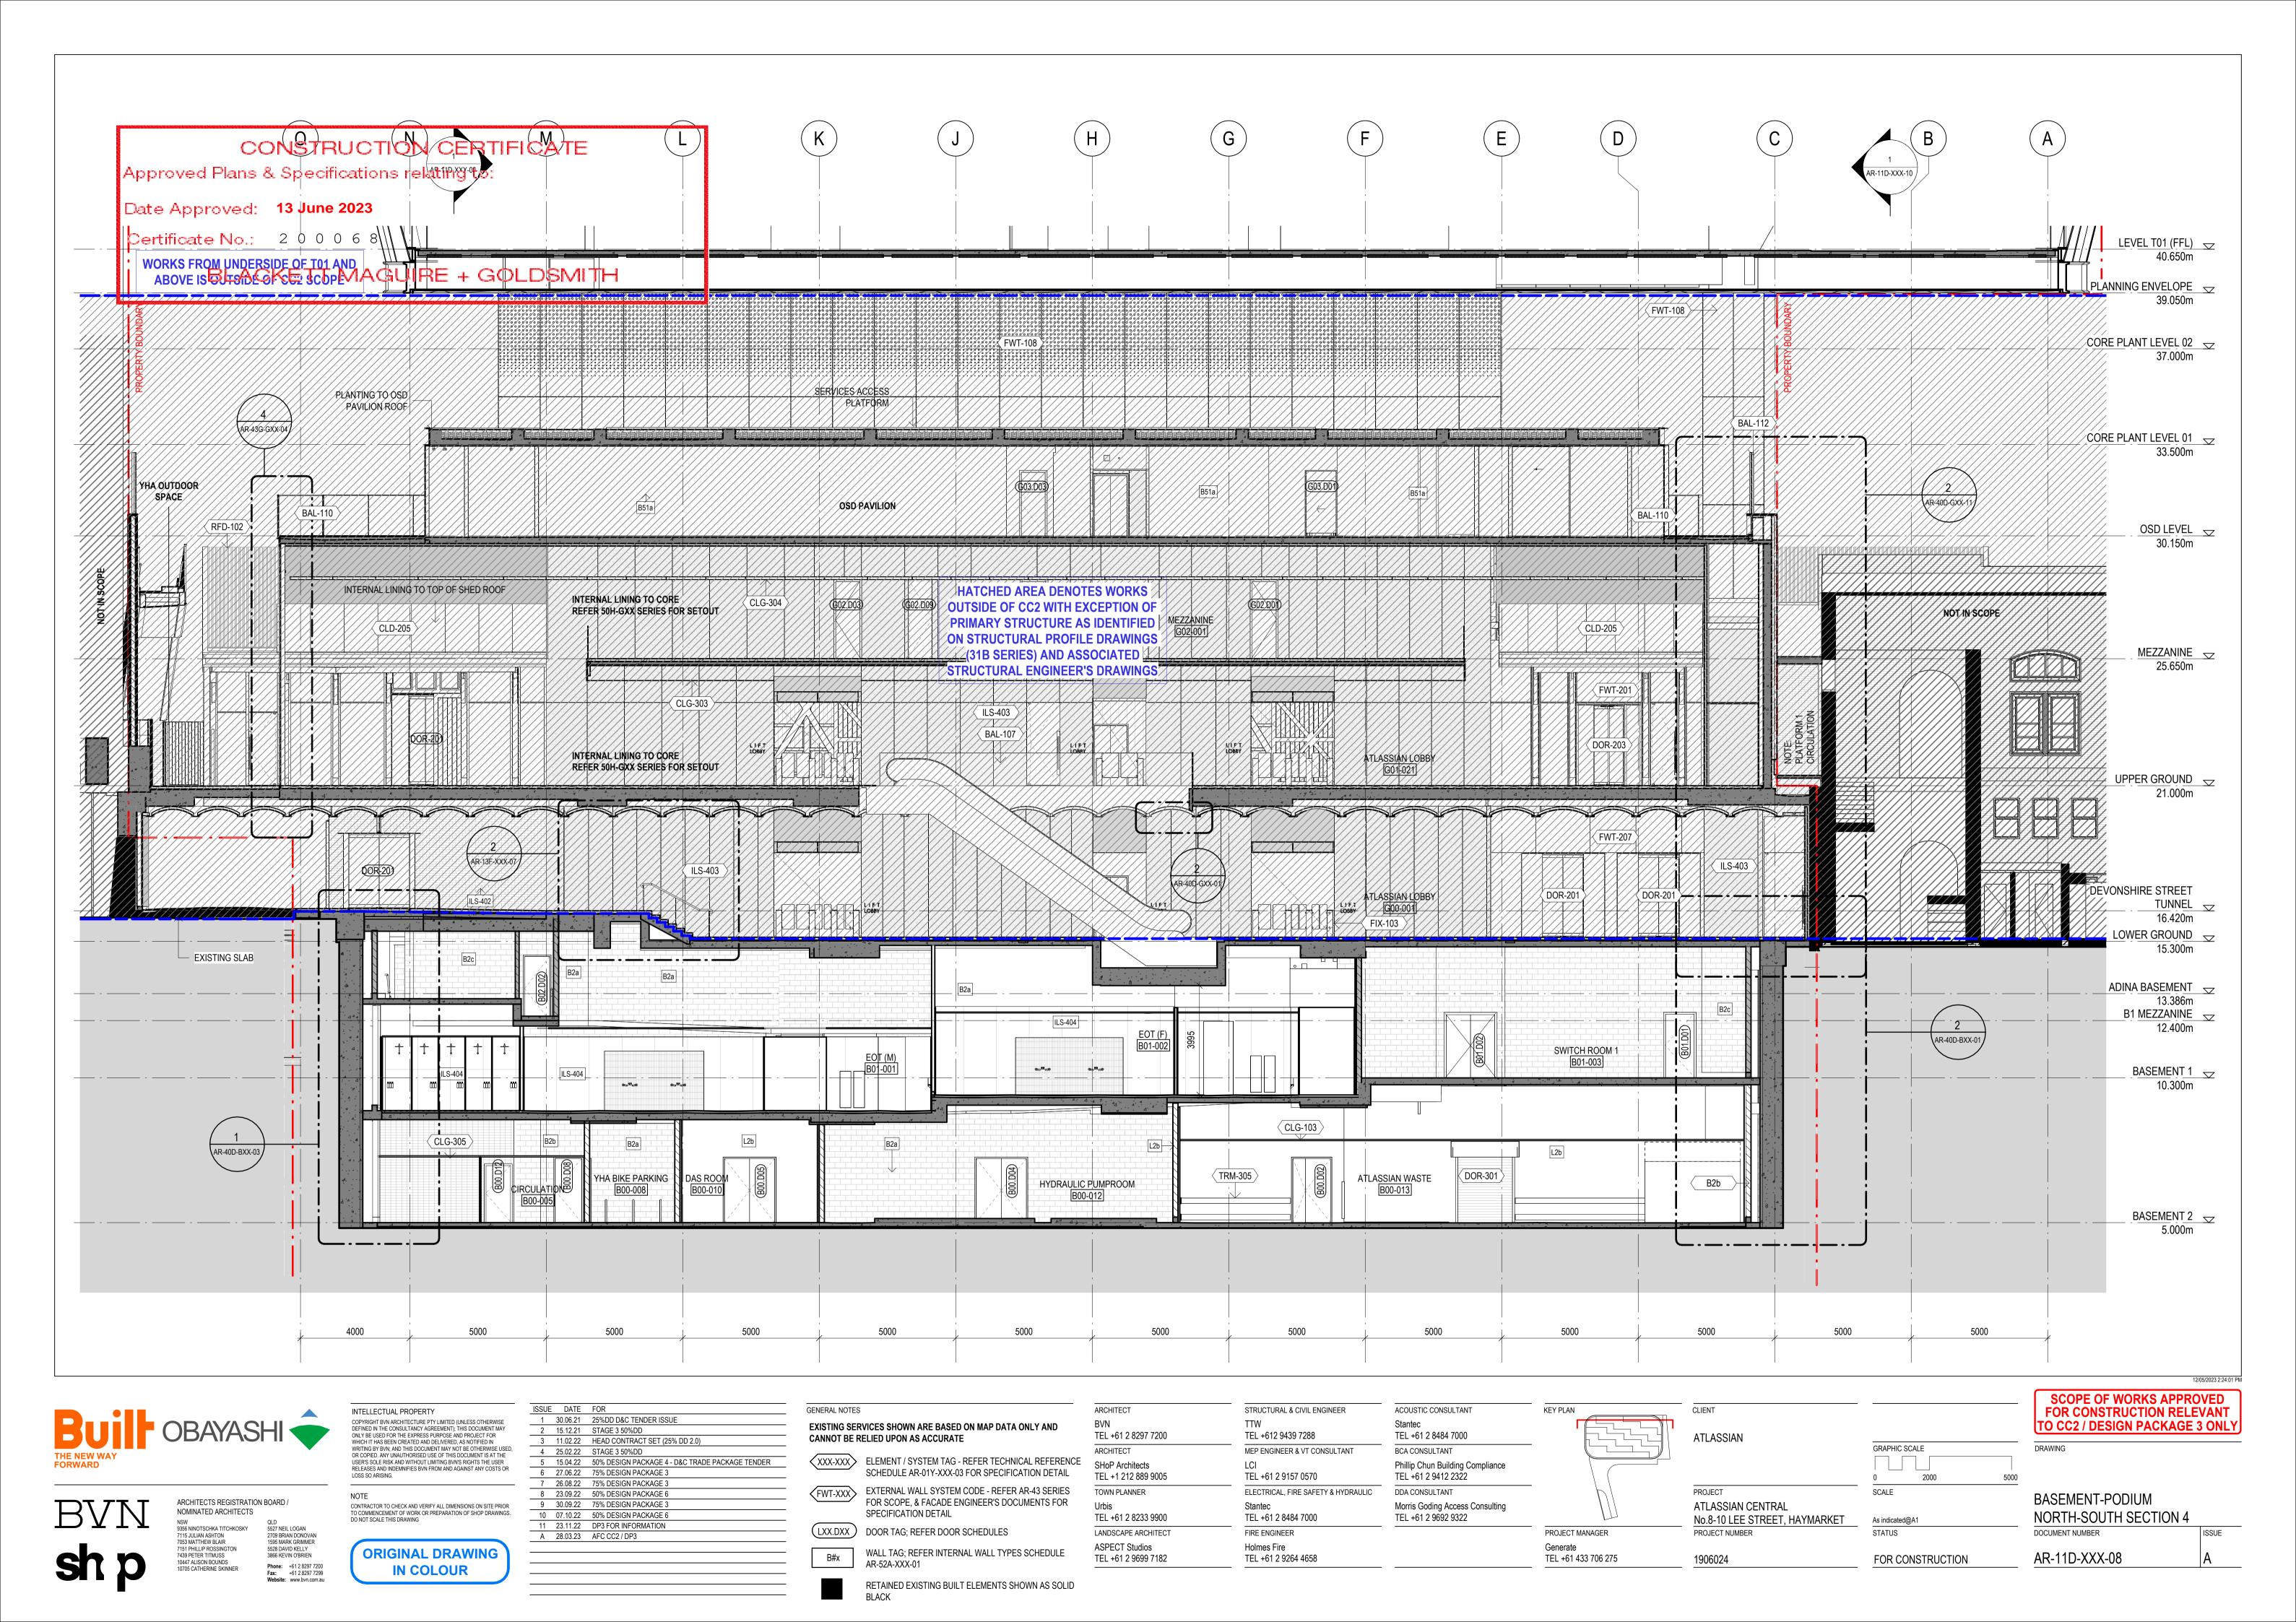

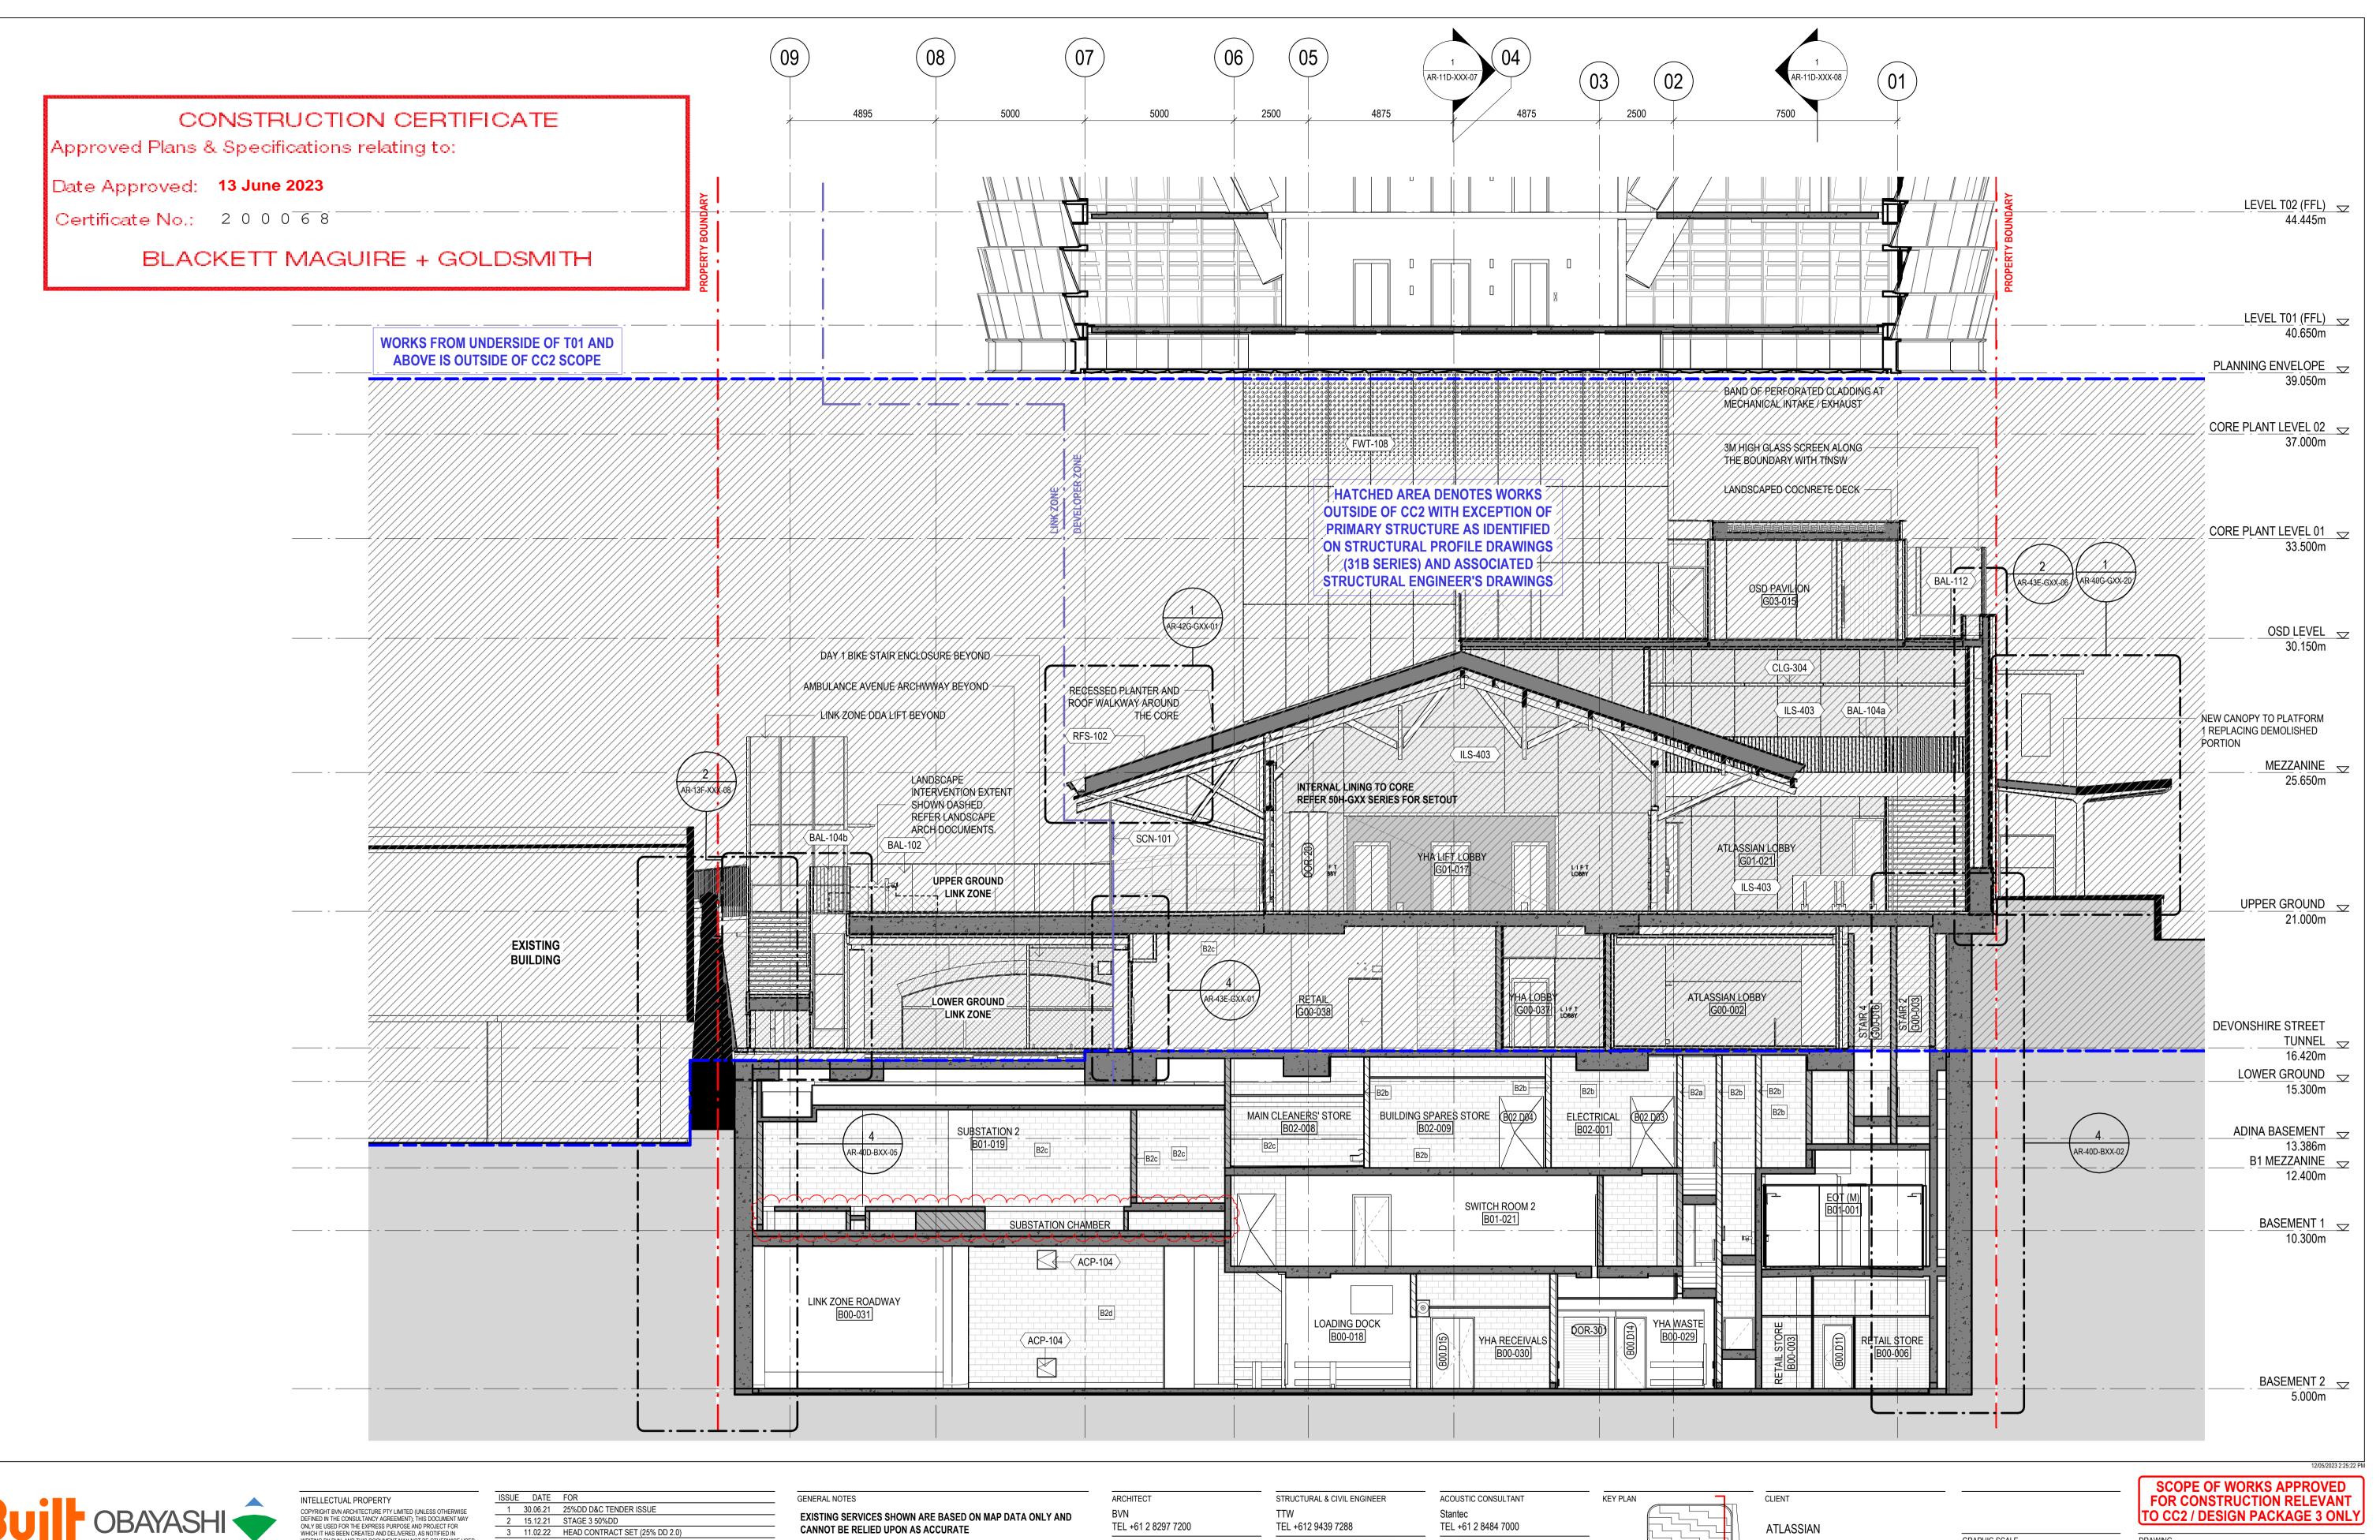



QLD 5527 NEIL LOGAN 2709 BRIAN DONOVAN 1595 MARK GRIMMER 5528 DAVID KELLY 3866 KEVIN O'BRIEN 7115 JULIAN ASHTON 7053 MATTHEW BLAIR 7151 PHILLIP ROSSINGTON 7439 PETER TITMUSS 10447 ALISON BOUNDS 10705 CATHERINE SKINNER Phone: +61 2 8297 7200 Fax: +61 2 8297 7299 Website: www.bvn.com.au WRITING BY BVN; AND THIS DOCUMENT MAY NOT BE OTHERWISE USED, OR COPIED. ANY UNAUTHORISED USE OF THIS DOCUMENT IS AT THE USER'S SOLE RISK AND WITHOUT LIMITING BVN'S RIGHTS THE USER RELEASES AND INDEMNIFIES BVN FROM AND AGAINST ANY COSTS OR CONTRACTOR TO CHECK AND VERIFY ALL DIMENSIONS ON SITE PRIOR

ORIGINAL DRAWING

IN COLOUR

ISSUE	DATE	FOR
1	30.06.21	25%DD D&C TENDER ISSUE
2	15.12.21	STAGE 3 50%DD
3	11.02.22	HEAD CONTRACT SET (25% DD 2.0)
4	25.02.22	STAGE 3 50%DD
5	15.04.22	50% DESIGN PACKAGE 4 - D&C TRADE PACKAGE TENDER
6	27.06.22	75% DESIGN PACKAGE 3
7	26.08.22	75% DESIGN PACKAGE 3
8	23.09.22	50% DESIGN PACKAGE 6
9	30.09.22	75% DESIGN PACKAGE 3
10	07.10.22	50% DESIGN PACKAGE 6
11	28.10.22	50% DESIGN PACKAGE 6
12	23.11.22	DP3 FOR INFORMATION
Α	28.03.23	AFC CC2 / DP3

CANNOT BE RELIED UPON AS ACCURATE

ELEMENT / SYSTEM TAG - REFER TECHNICAL REFERENCE SCHEDULE AR-01Y-XXX-03 FOR SPECIFICATION DETAIL FWT-XXX EXTERNAL WALL SYSTEM CODE - REFER AR-43 SERIES FOR SCOPE, & FACADE ENGINEER'S DOCUMENTS FOR SPECIFICATION DETAIL



(LXX.DXX) DOOR TAG; REFER DOOR SCHEDULES WALL TAG; REFER INTERNAL WALL TYPES SCHEDULE

LANDSCAPE ARCHITECT ASPECT Studios TEL +61 2 9699 7182

TEL +612 9439 7288 MEP ENGINEER & VT CONSULTANT TEL +61 2 9157 0570 TEL +1 212 889 9005 TOWN PLANNER


TEL +61 2 8233 9900


ELECTRICAL, FIRE SAFETY & HYDRAULIC TEL +61 2 8484 7000 FIRE ENGINEER Holmes Fire

TEL +61 2 9264 4658

BCA CONSULTANT

DDA CONSULTANT

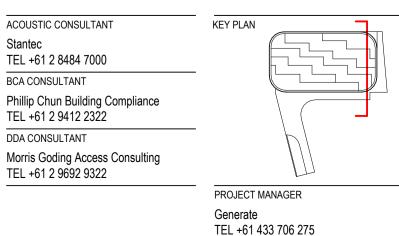

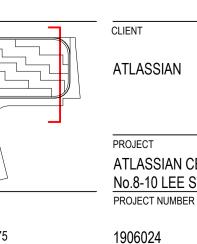


GRAPHIC SCALE SCALE ATLASSIAN CENTRAL No.8-10 LEE STREET, HAYMARKET As indicated@A1 STATUS

DRAWING

BASEMENT-PODIUM EAST-WEST SECTION 3 DOCUMENT NUMBER

RETAINED EXISTING BUILT ELEMENTS SHOWN AS SOLID

1906024 FOR CONSTRUCTION AR-11D-XXX-09

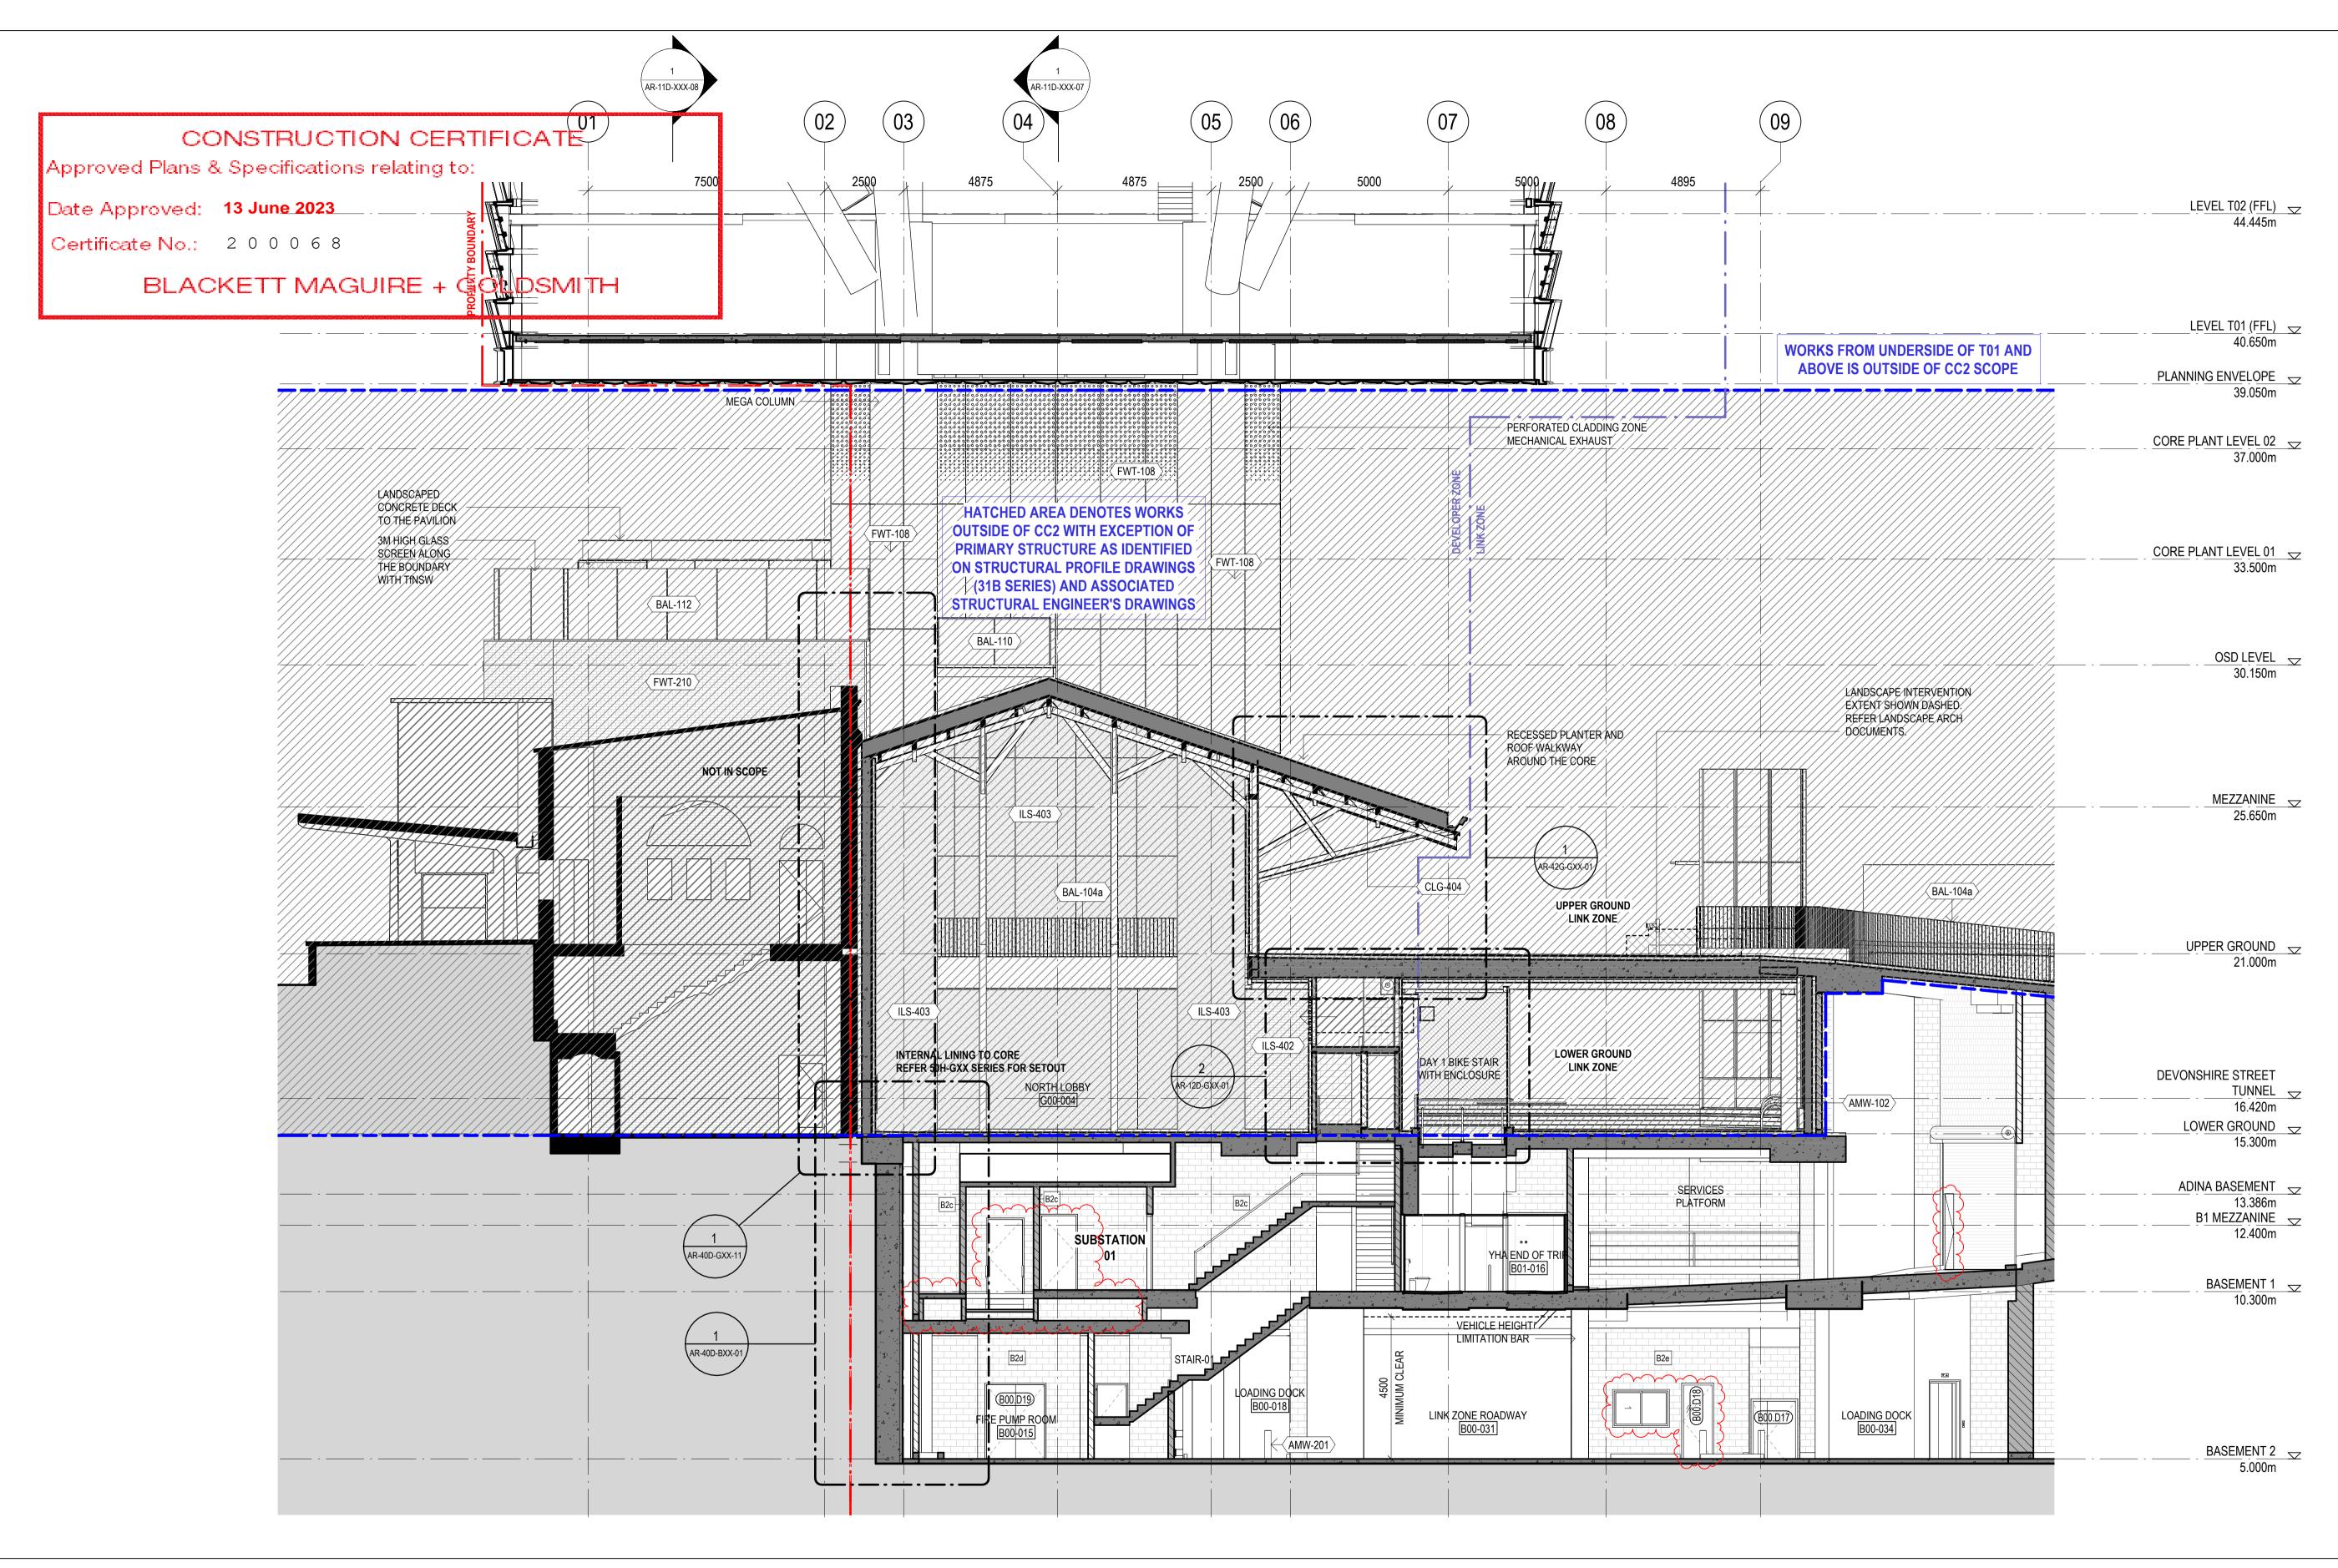



QLD 5527 NEIL LOGAN 2709 BRIAN DONOVAN 1595 MARK GRIMMER 5528 DAVID KELLY 3866 KEVIN O'BRIEN 7115 JULIAN ASHTON 7053 MATTHEW BLAIR 7151 PHILLIP ROSSINGTON 7439 PETER TITMUSS 10447 ALISON BOUNDS 10705 CATHERINE SKINNER Phone: +61 2 8297 7200 Fax: +61 2 8297 7299 Website: www.bvn.com.au INTELLECTUAL PROPERTY COPYRIGHT BVN ARCHITECTURE PTY LIMITED (UNLESS OTHERWISE DEFINED IN THE CONSULTANCY AGREEMENT); THIS DOCUMENT MAY ONLY BE USED FOR THE EXPRESS PURPOSE AND PROJECT FOR WHICH IT HAS BEEN CREATED AND DELIVERED, AS NOTIFIED IN WRITING BY BVN; AND THIS DOCUMENT MAY NOT BE OTHERWISE USED, OR COPIED. ANY UNAUTHORISED USE OF THIS DOCUMENT IS AT THE USER'S SOLE RISK AND WITHOUT LIMITING BVN'S RIGHTS THE USER RELEASES AND INDEMNIFIES BVN FROM AND AGAINST ANY COSTS OR LOSS SO ARISING.

CONTRACTOR TO CHECK AND VERIFY ALL DIMENSIONS ON SITE PRIOR

ORIGINAL DRAWING IN COLOUR

ISSUE DATE FOR 1 30.06.21 25%DD D&C TENDER ISSUE 2 15.12.21 STAGE 3 50%DD 3 11.02.22 HEAD CONTRACT SET (25% DD 2.0) 4 25.02.22 STAGE 3 50%DD 5 15.04.22 50% DESIGN PACKAGE 4 - D&C TRADE PACKAGE TENDER 6 27.06.22 75% DESIGN PACKAGE 3 7 26.08.22 75% DESIGN PACKAGE 3 8 23.09.22 50% DESIGN PACKAGE 6 9 30.09.22 75% DESIGN PACKAGE 3

11 28.10.22 50% DESIGN PACKAGE 6

12 23.11.22 DP3 FOR INFORMATION

A 28.03.23 AFC CC2 / DP3

EXISTING SERVICES SHOWN ARE BASED ON MAP DATA ONLY AND CANNOT BE RELIED UPON AS ACCURATE XXX-XXX ELEMENT / SYSTEM TAG - REFER TECHNICAL REFERENCE SCHEDULE AR-01Y-XXX-03 FOR SPECIFICATION DETAIL FWT-XXX EXTERNAL WALL SYSTEM CODE - REFER AR-43 SERIES FOR SCOPE, & FACADE ENGINEER'S DOCUMENTS FOR SPECIFICATION DETAIL 10 07.10.22 50% DESIGN PACKAGE 6

GENERAL NOTES

AR-52A-XXX-01

LXX.DXX) DOOR TAG; REFER DOOR SCHEDULES WALL TAG; REFER INTERNAL WALL TYPES SCHEDULE

ARCHITECT STRUCTURAL & CIVIL ENGINEER TEL +61 2 8297 7200 TEL +612 9439 7288 MEP ENGINEER & VT CONSULTANT

ARCHITECT SHoP Architects TEL +1 212 889 9005 TOWN PLANNER TEL +61 2 8233 9900 LANDSCAPE ARCHITECT

ASPECT Studios


TEL +61 2 9699 7182

BCA CONSULTANT Phillip Chun Building Compliance TEL +61 2 9157 0570 TEL +61 2 9412 2322 ELECTRICAL, FIRE SAFETY & HYDRAULIC DDA CONSULTANT Morris Goding Access Consulting Stantec TEL +61 2 8484 7000 TEL +61 2 9692 9322 FIRE ENGINEER Holmes Fire

TEL +61 2 9264 4658

ACOUSTIC CONSULTANT

TEL +61 2 8484 7000

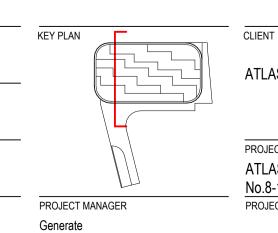

ATLASSIAN PROJECT ATLASSIAN CENTRAL No.8-10 LEE STREET, HAYMARKET PROJECT NUMBER

SCOPE OF WORKS APPROVED FOR CONSTRUCTION RELEVANT TO CC2 / DESIGN PACKAGE 3 ONLY GRAPHIC SCALE DRAWING SCALE

BASEMENT-PODIUM EAST-WEST SECTION 4 DOCUMENT NUMBER


RETAINED EXISTING BUILT ELEMENTS SHOWN AS SOLID


TEL +61 433 706 275 1906024

AR-11D-XXX-10 FOR CONSTRUCTION

As indicated@A1

STATUS

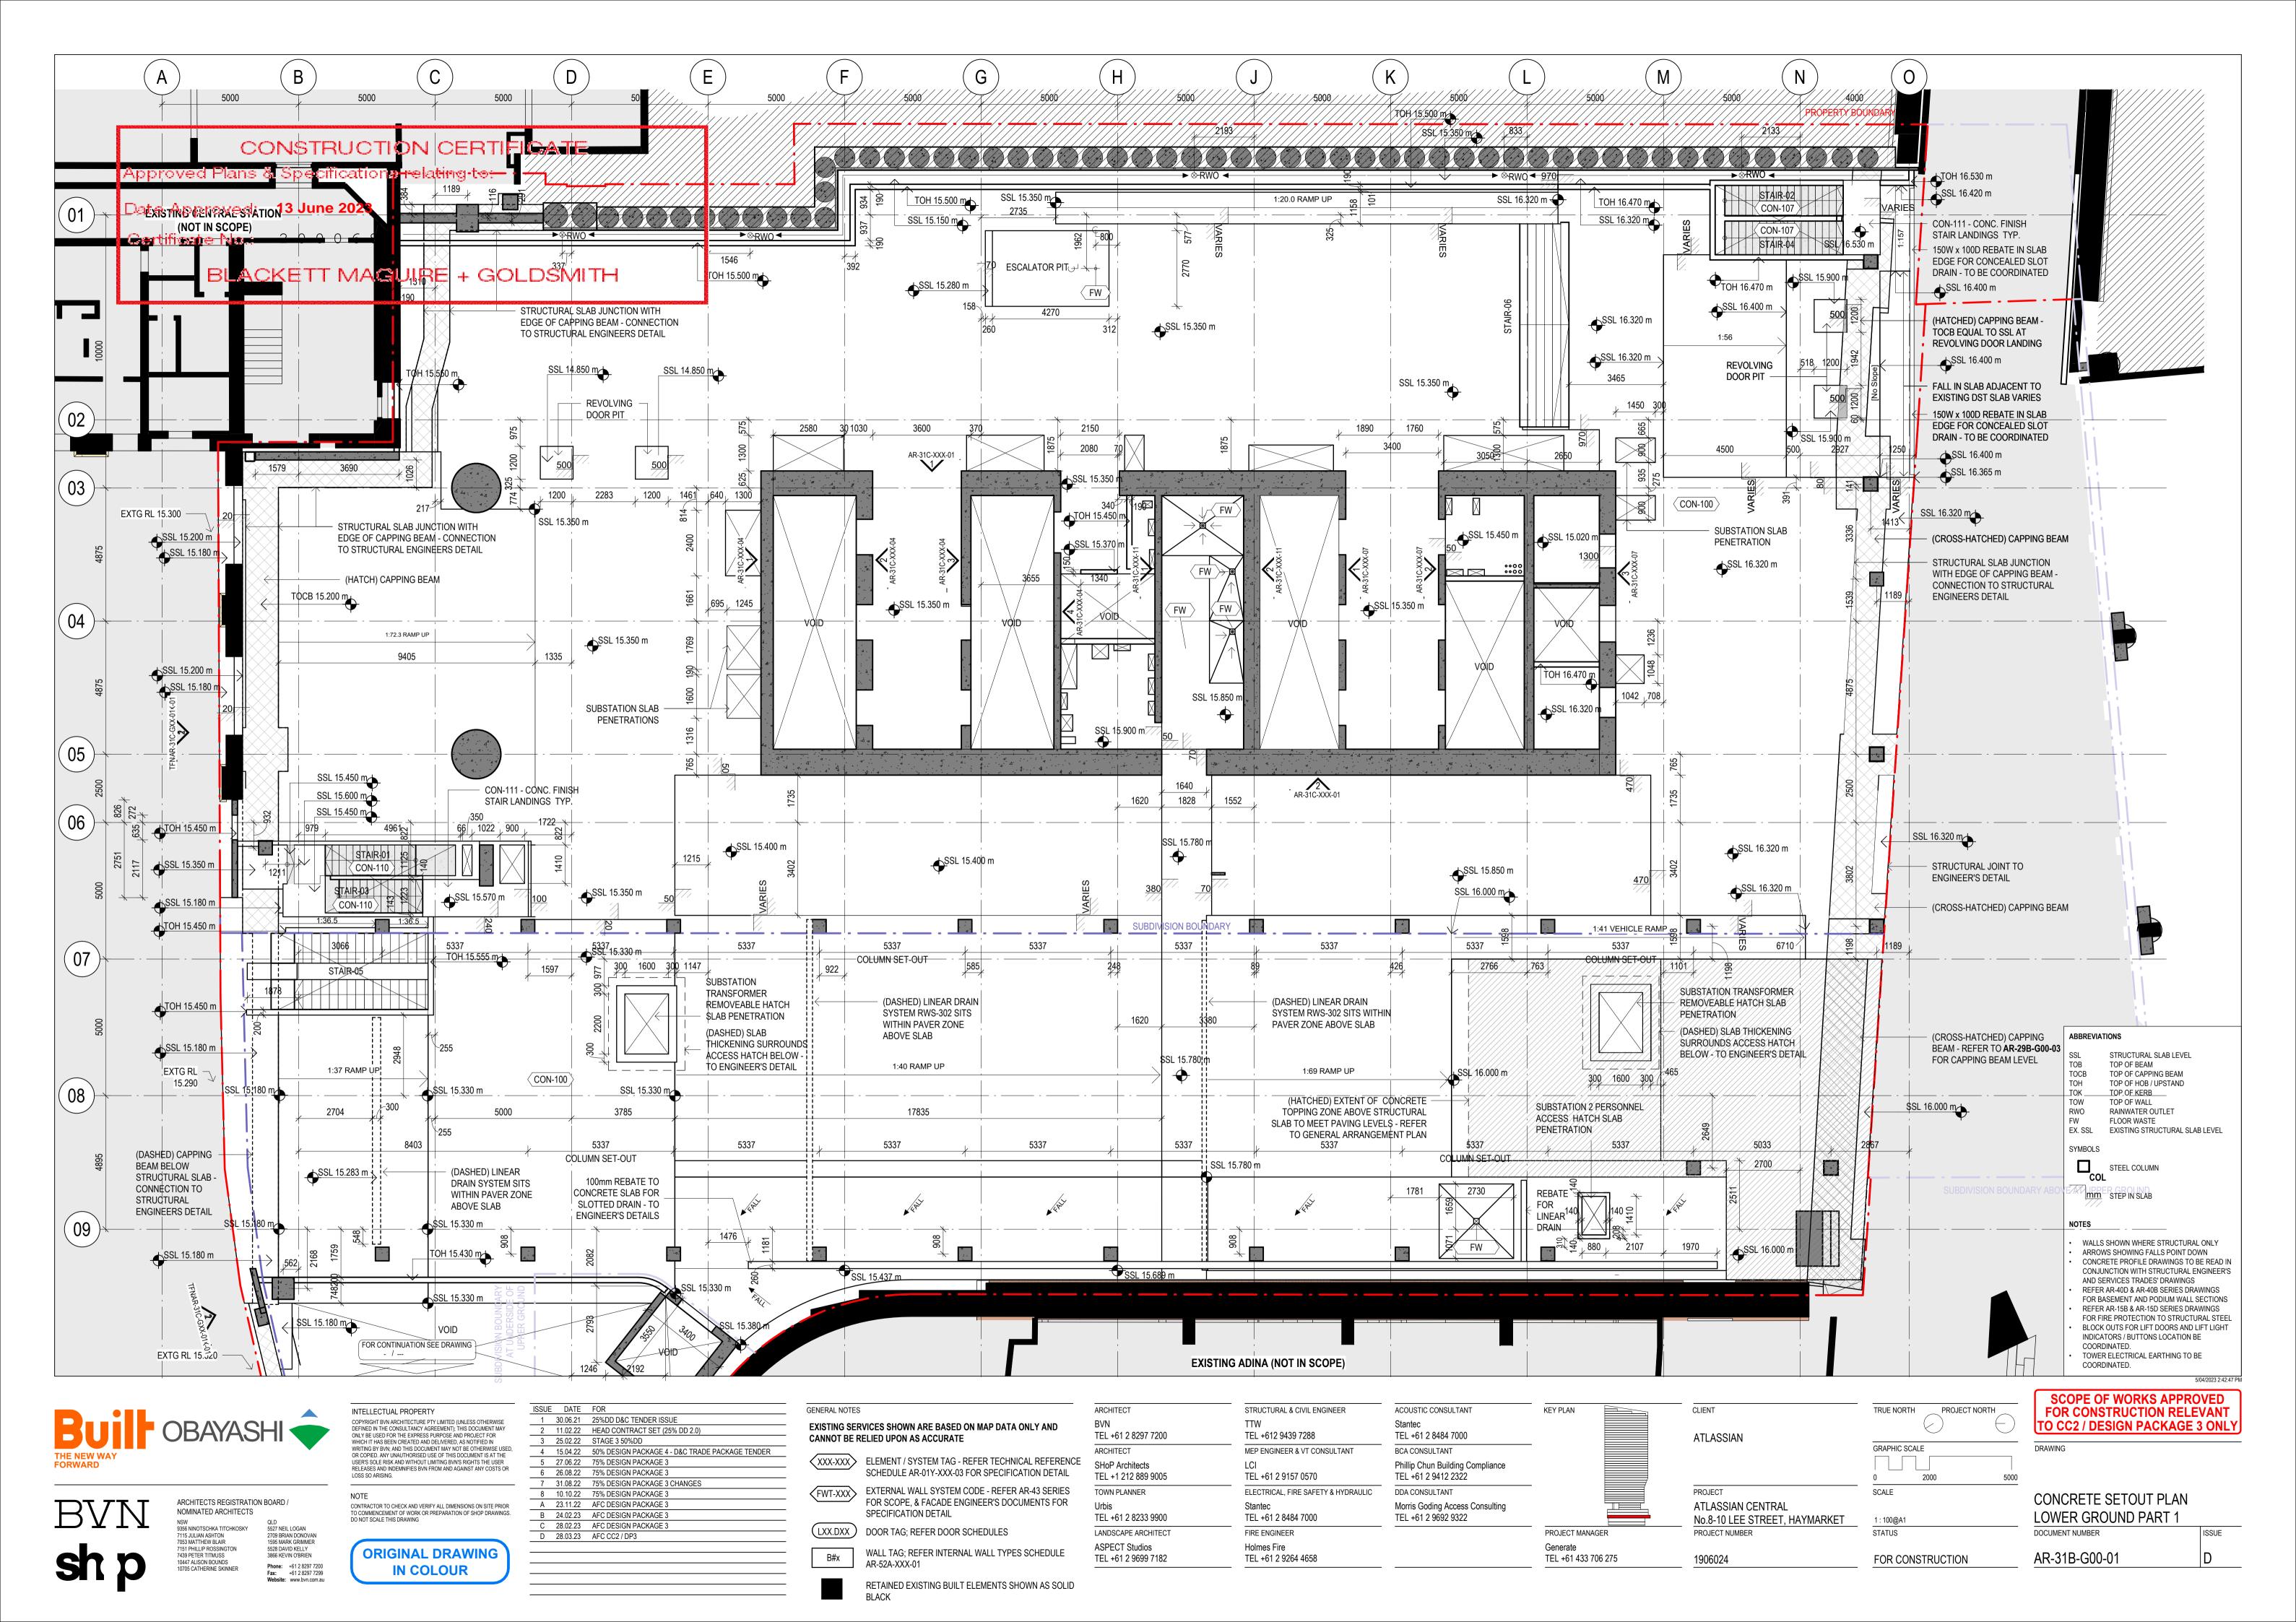

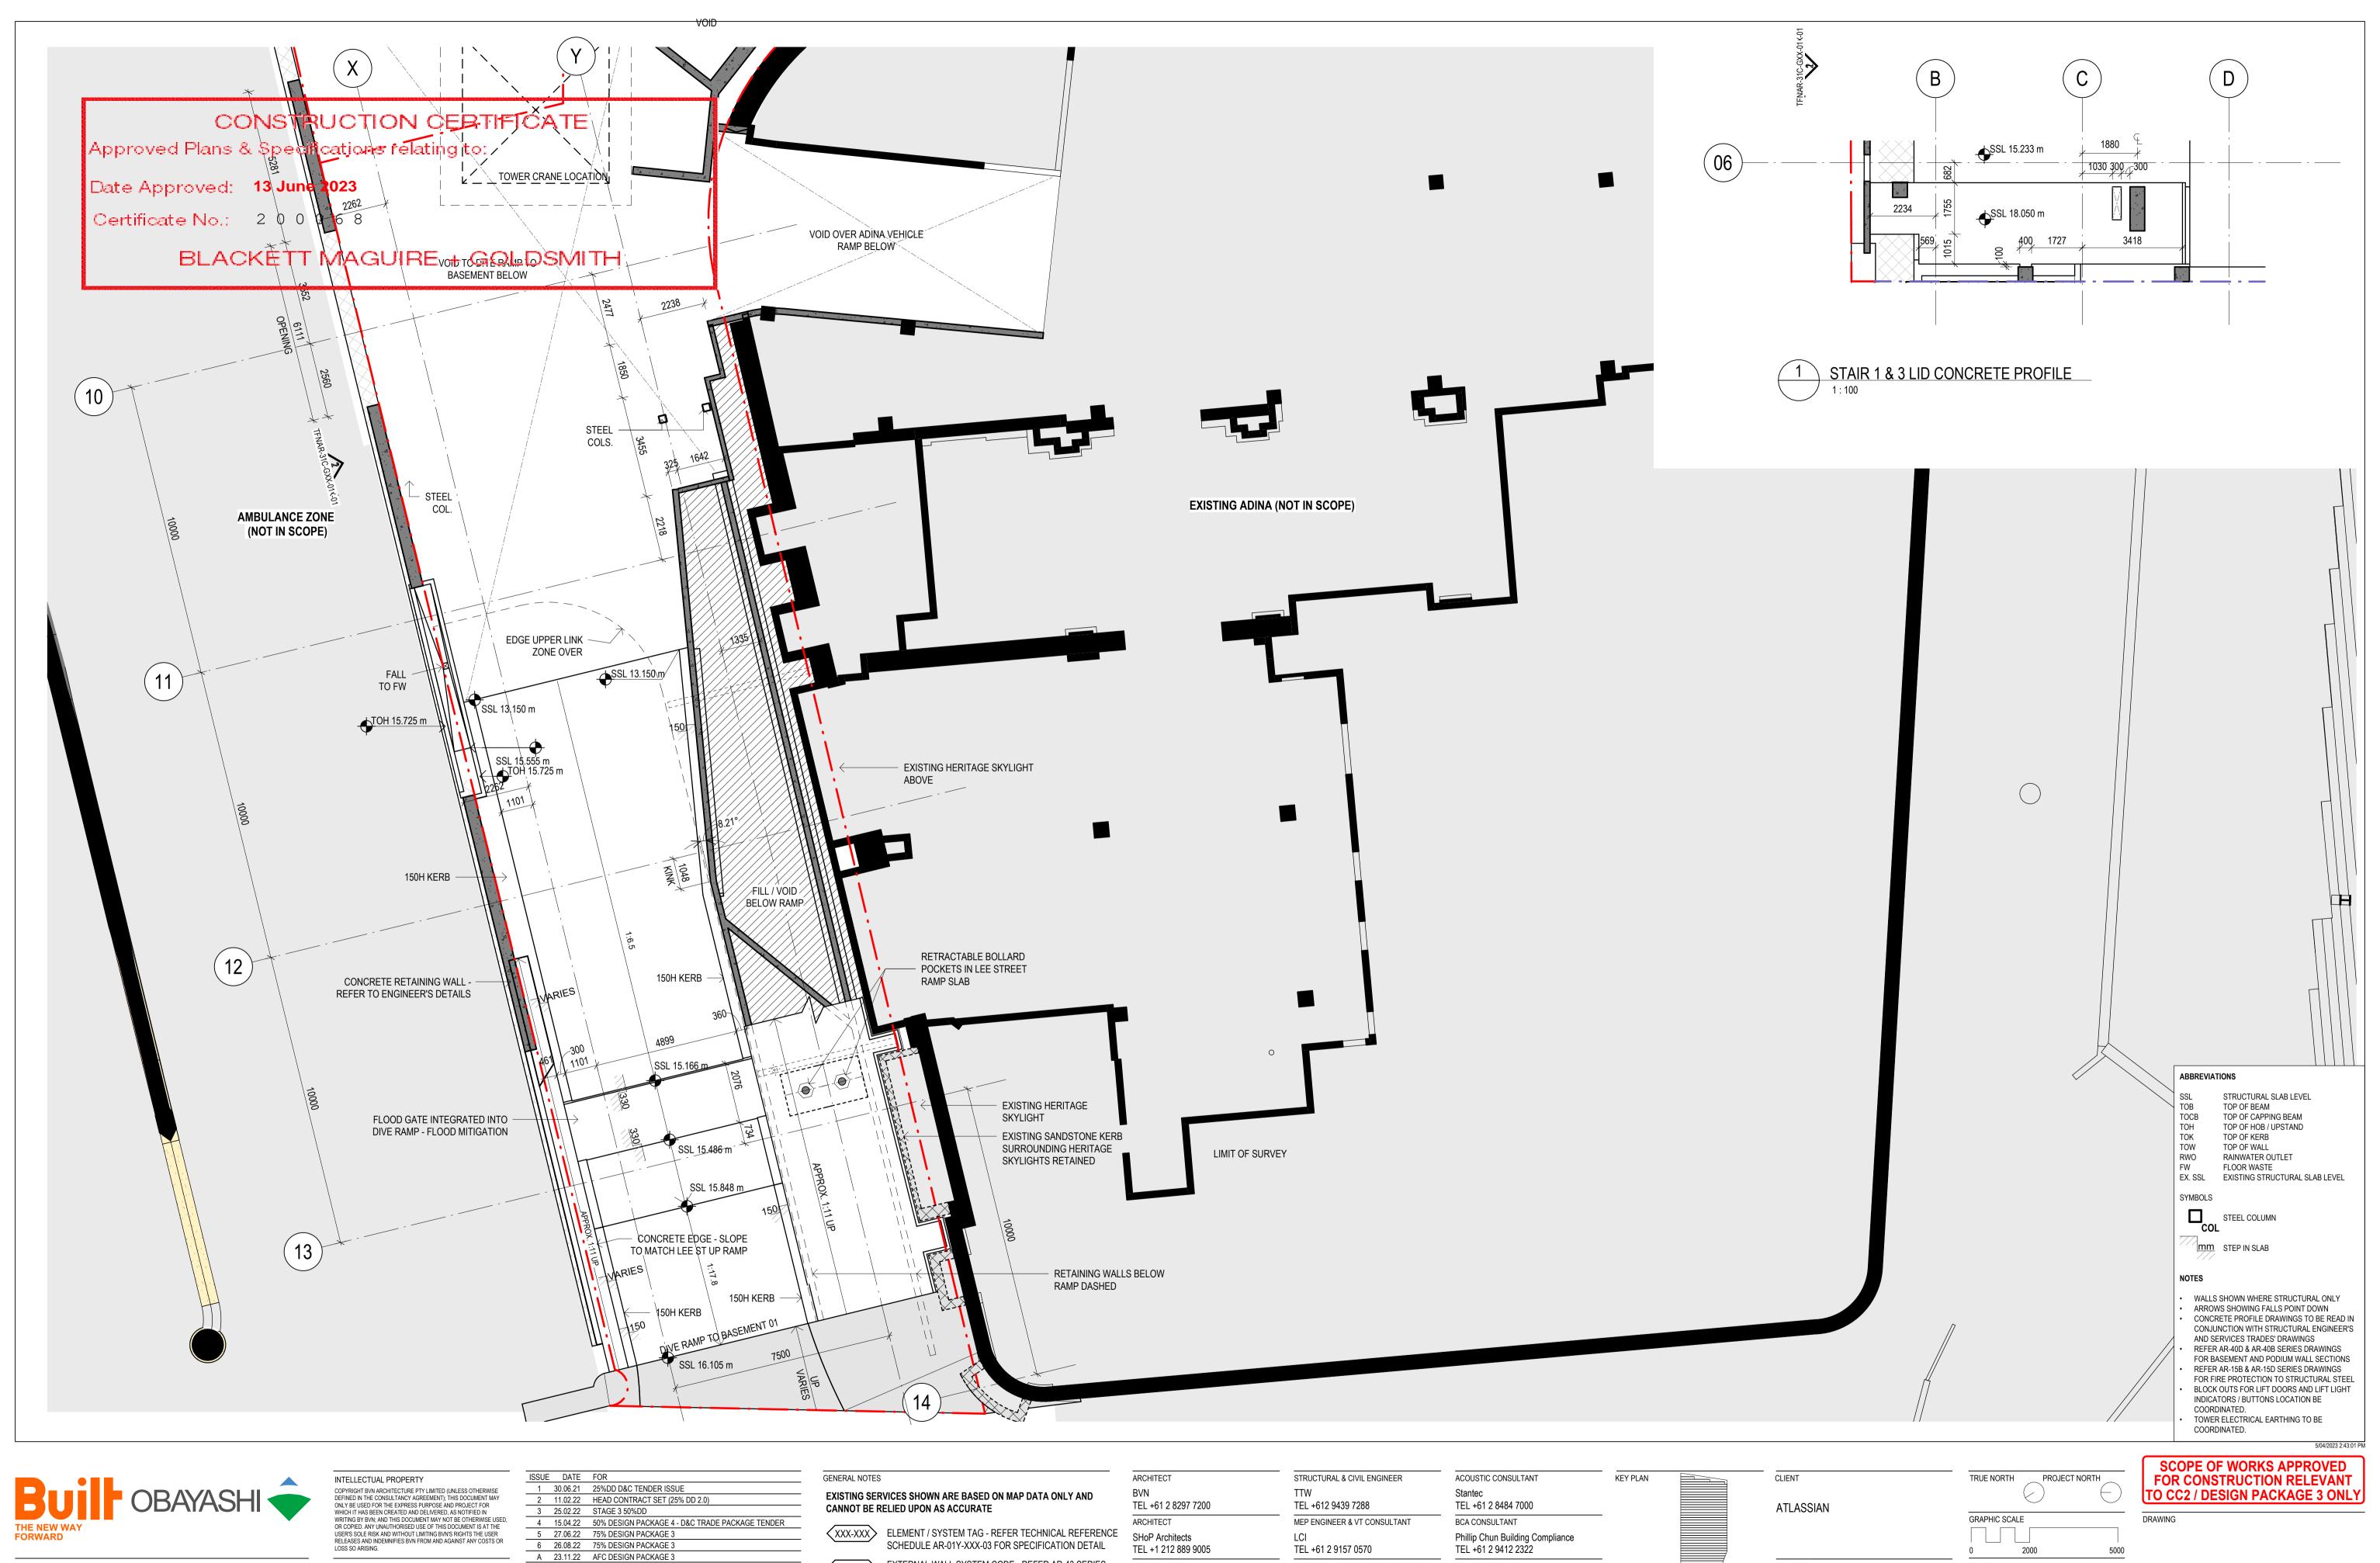

QLD 5227 NEIL LOGAN 2709 BRIAN DONOVAN 1595 MARK GRIMMER 5528 DAVID KELLY 3866 KEVIN O'BRIEN 7115 JULIAN ASHTON 7053 MATTHEW BLAIR 7151 PHILLIP ROSSINGTON 7439 PETER TITMUSS 10447 ALISON BOUNDS 10705 CATHERINE SKINNER Phone: +61 2 8297 7200 Fax: +61 2 8297 7299 Website: www.bvn.com.au LOSS SO ARISING.

CONTRACTOR TO CHECK AND VERIFY ALL DIMENSIONS ON SITE PRIOR TO COMMENCEMENT OF WORK OR PREPARATION OF SHOP DRAWINGS. DO NOT SCALE THIS DRAWING

B 28.03.23 AFC CC2 / DP3

ORIGINAL DRAWING IN COLOUR

FWT-XXX EXTERNAL WALL SYSTEM CODE - REFER AR-43 SERIES FOR SCOPE, & FACADE ENGINEER'S DOCUMENTS FOR

SPECIFICATION DETAIL

LXX.DXX) DOOR TAG; REFER DOOR SCHEDULES WALL TAG; REFER INTERNAL WALL TYPES SCHEDULE AR-52A-XXX-01

TEL +1 212 889 9005 TOWN PLANNER TEL +61 2 8233 9900 LANDSCAPE ARCHITECT ASPECT Studios TEL +61 2 9699 7182 TEL +61 2 9157 0570

ELECTRICAL, FIRE SAFETY & HYDRAULIC Stantec TEL +61 2 8484 7000 FIRE ENGINEER Holmes Fire

TEL +61 2 9264 4658

DDA CONSULTANT

TEL +61 2 9692 9322

Morris Goding Access Consulting

PROJECT MANAGER Generate TEL +61 433 706 275

PROJECT NUMBER 1906024


PROJECT ATLASSIAN CENTRAL No.8-10 LEE STREET, HAYMARKET


2000 SCALE 1:100@A1 STATUS

FOR CONSTRUCTION

CONCRETE SETOUT PLAN LOWER GROUND PART 2 DOCUMENT NUMBER

AR-31B-G00-02

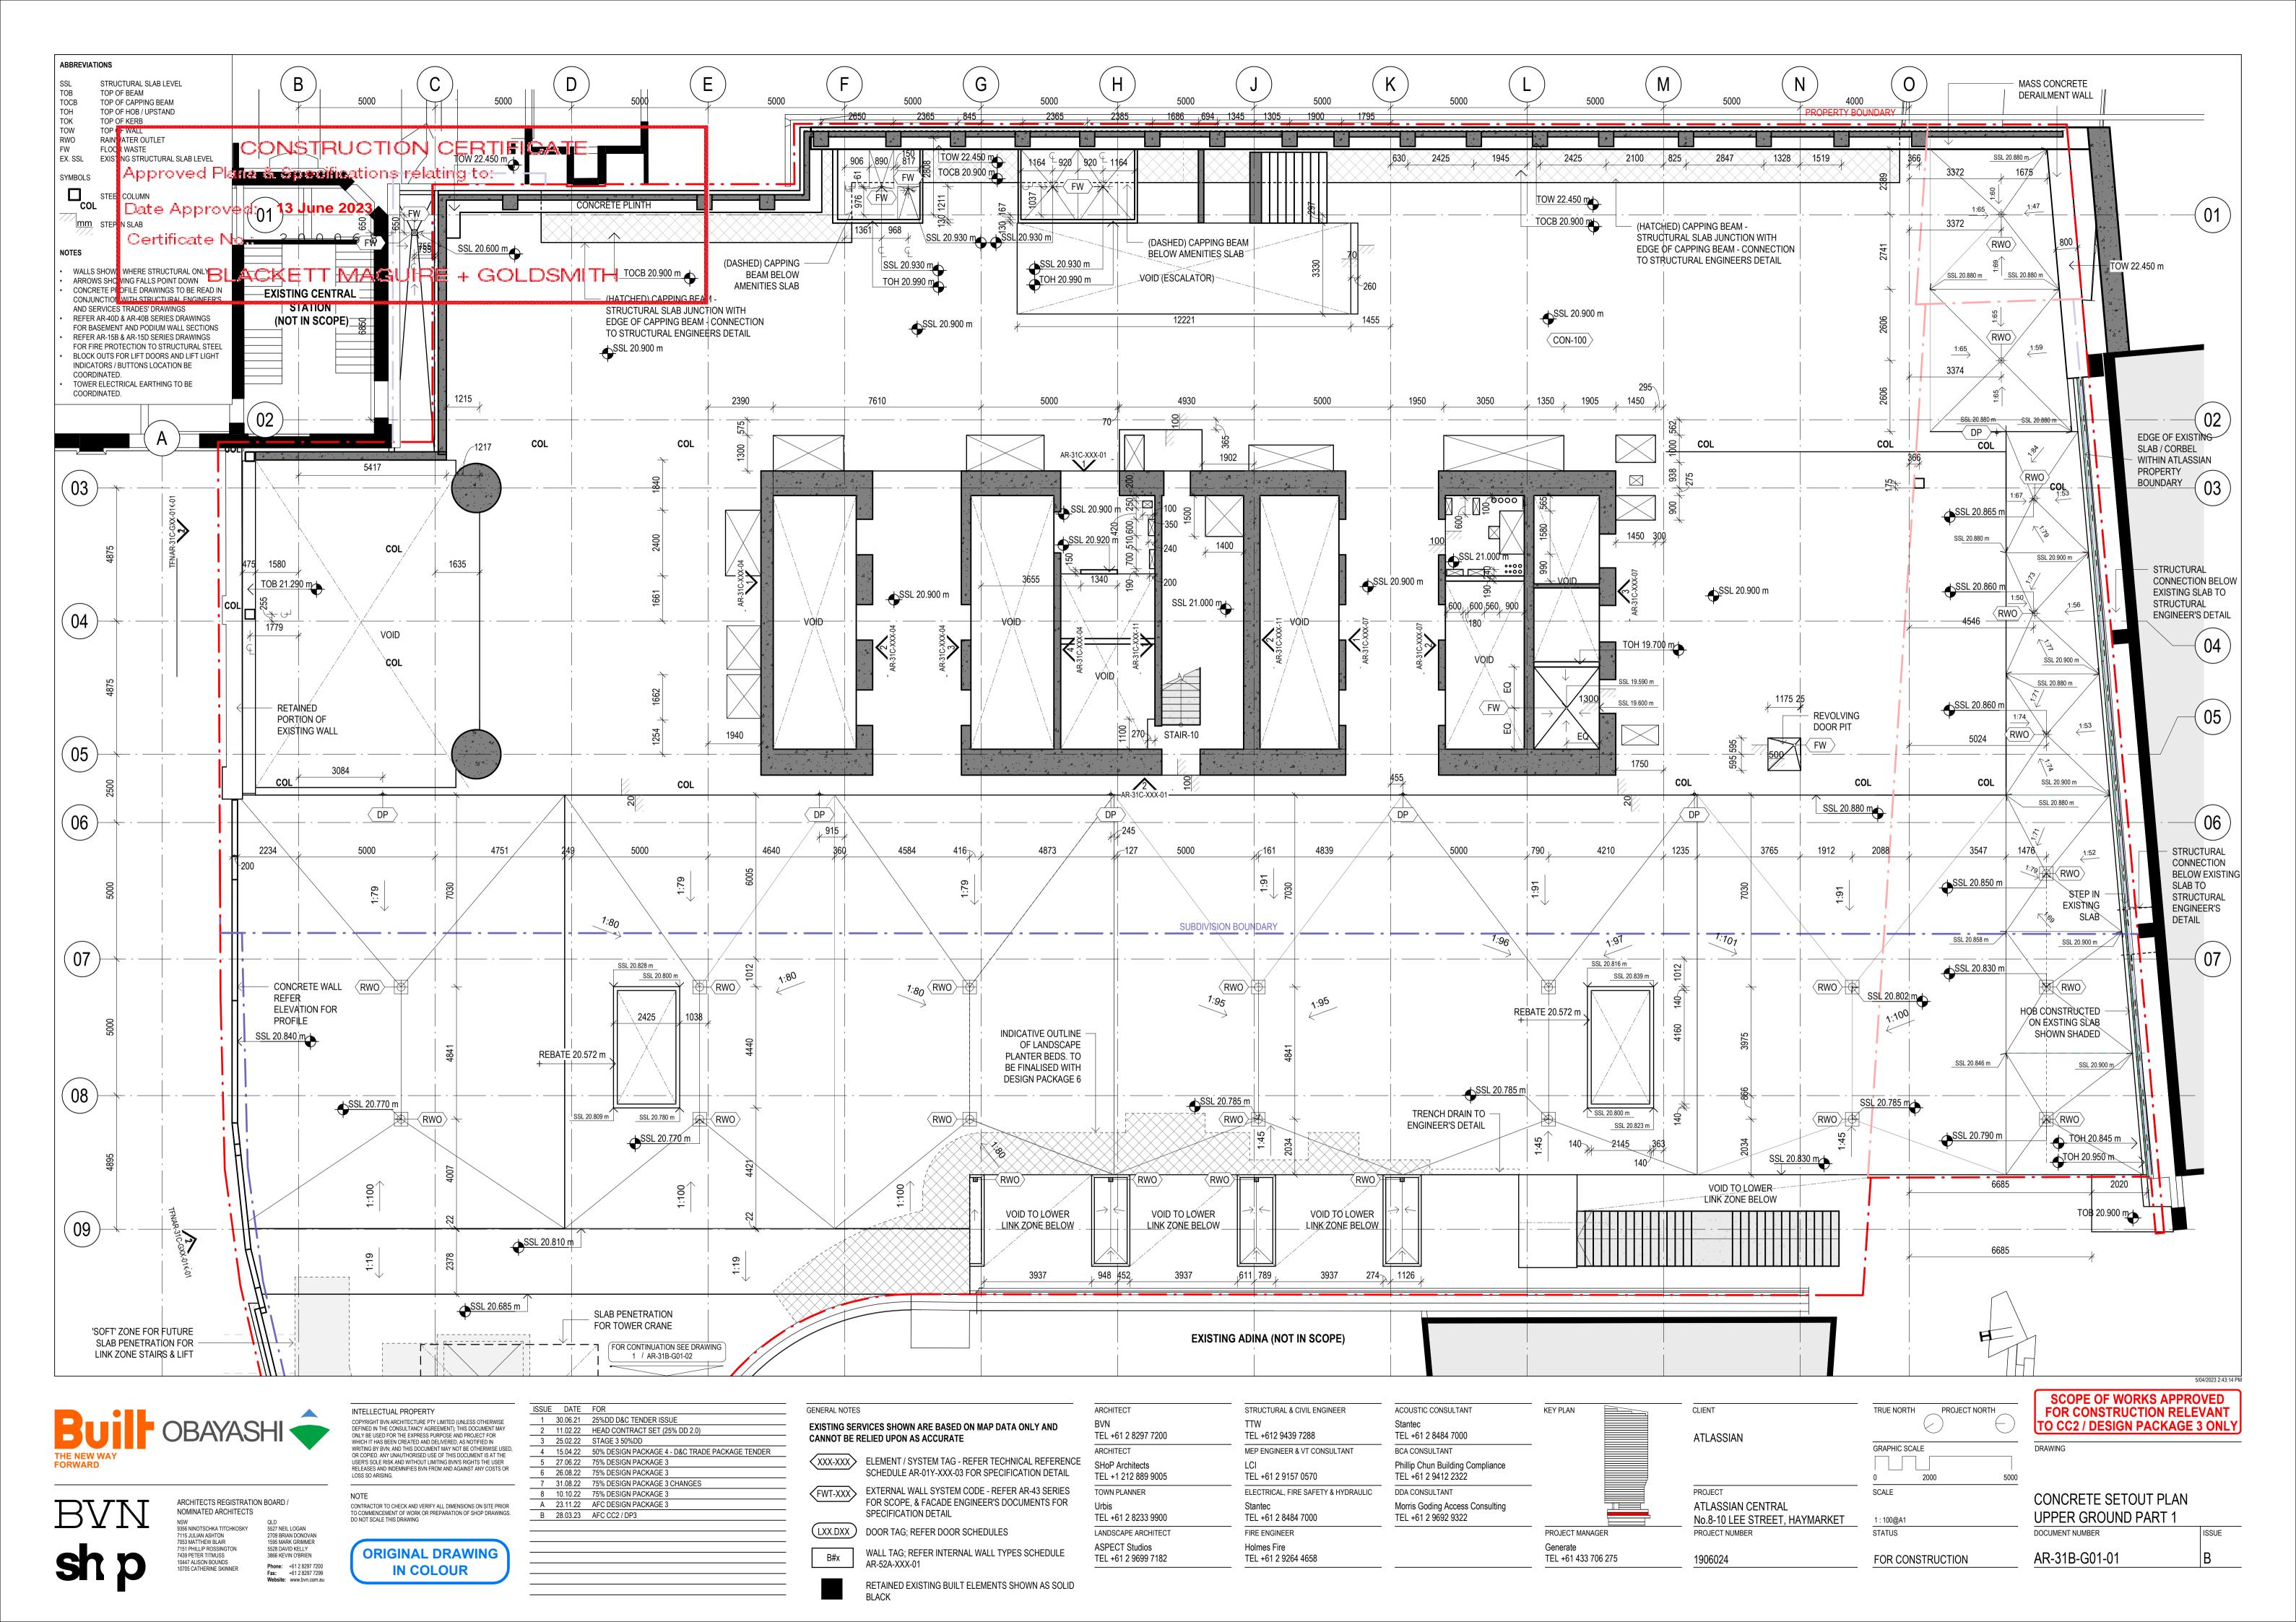

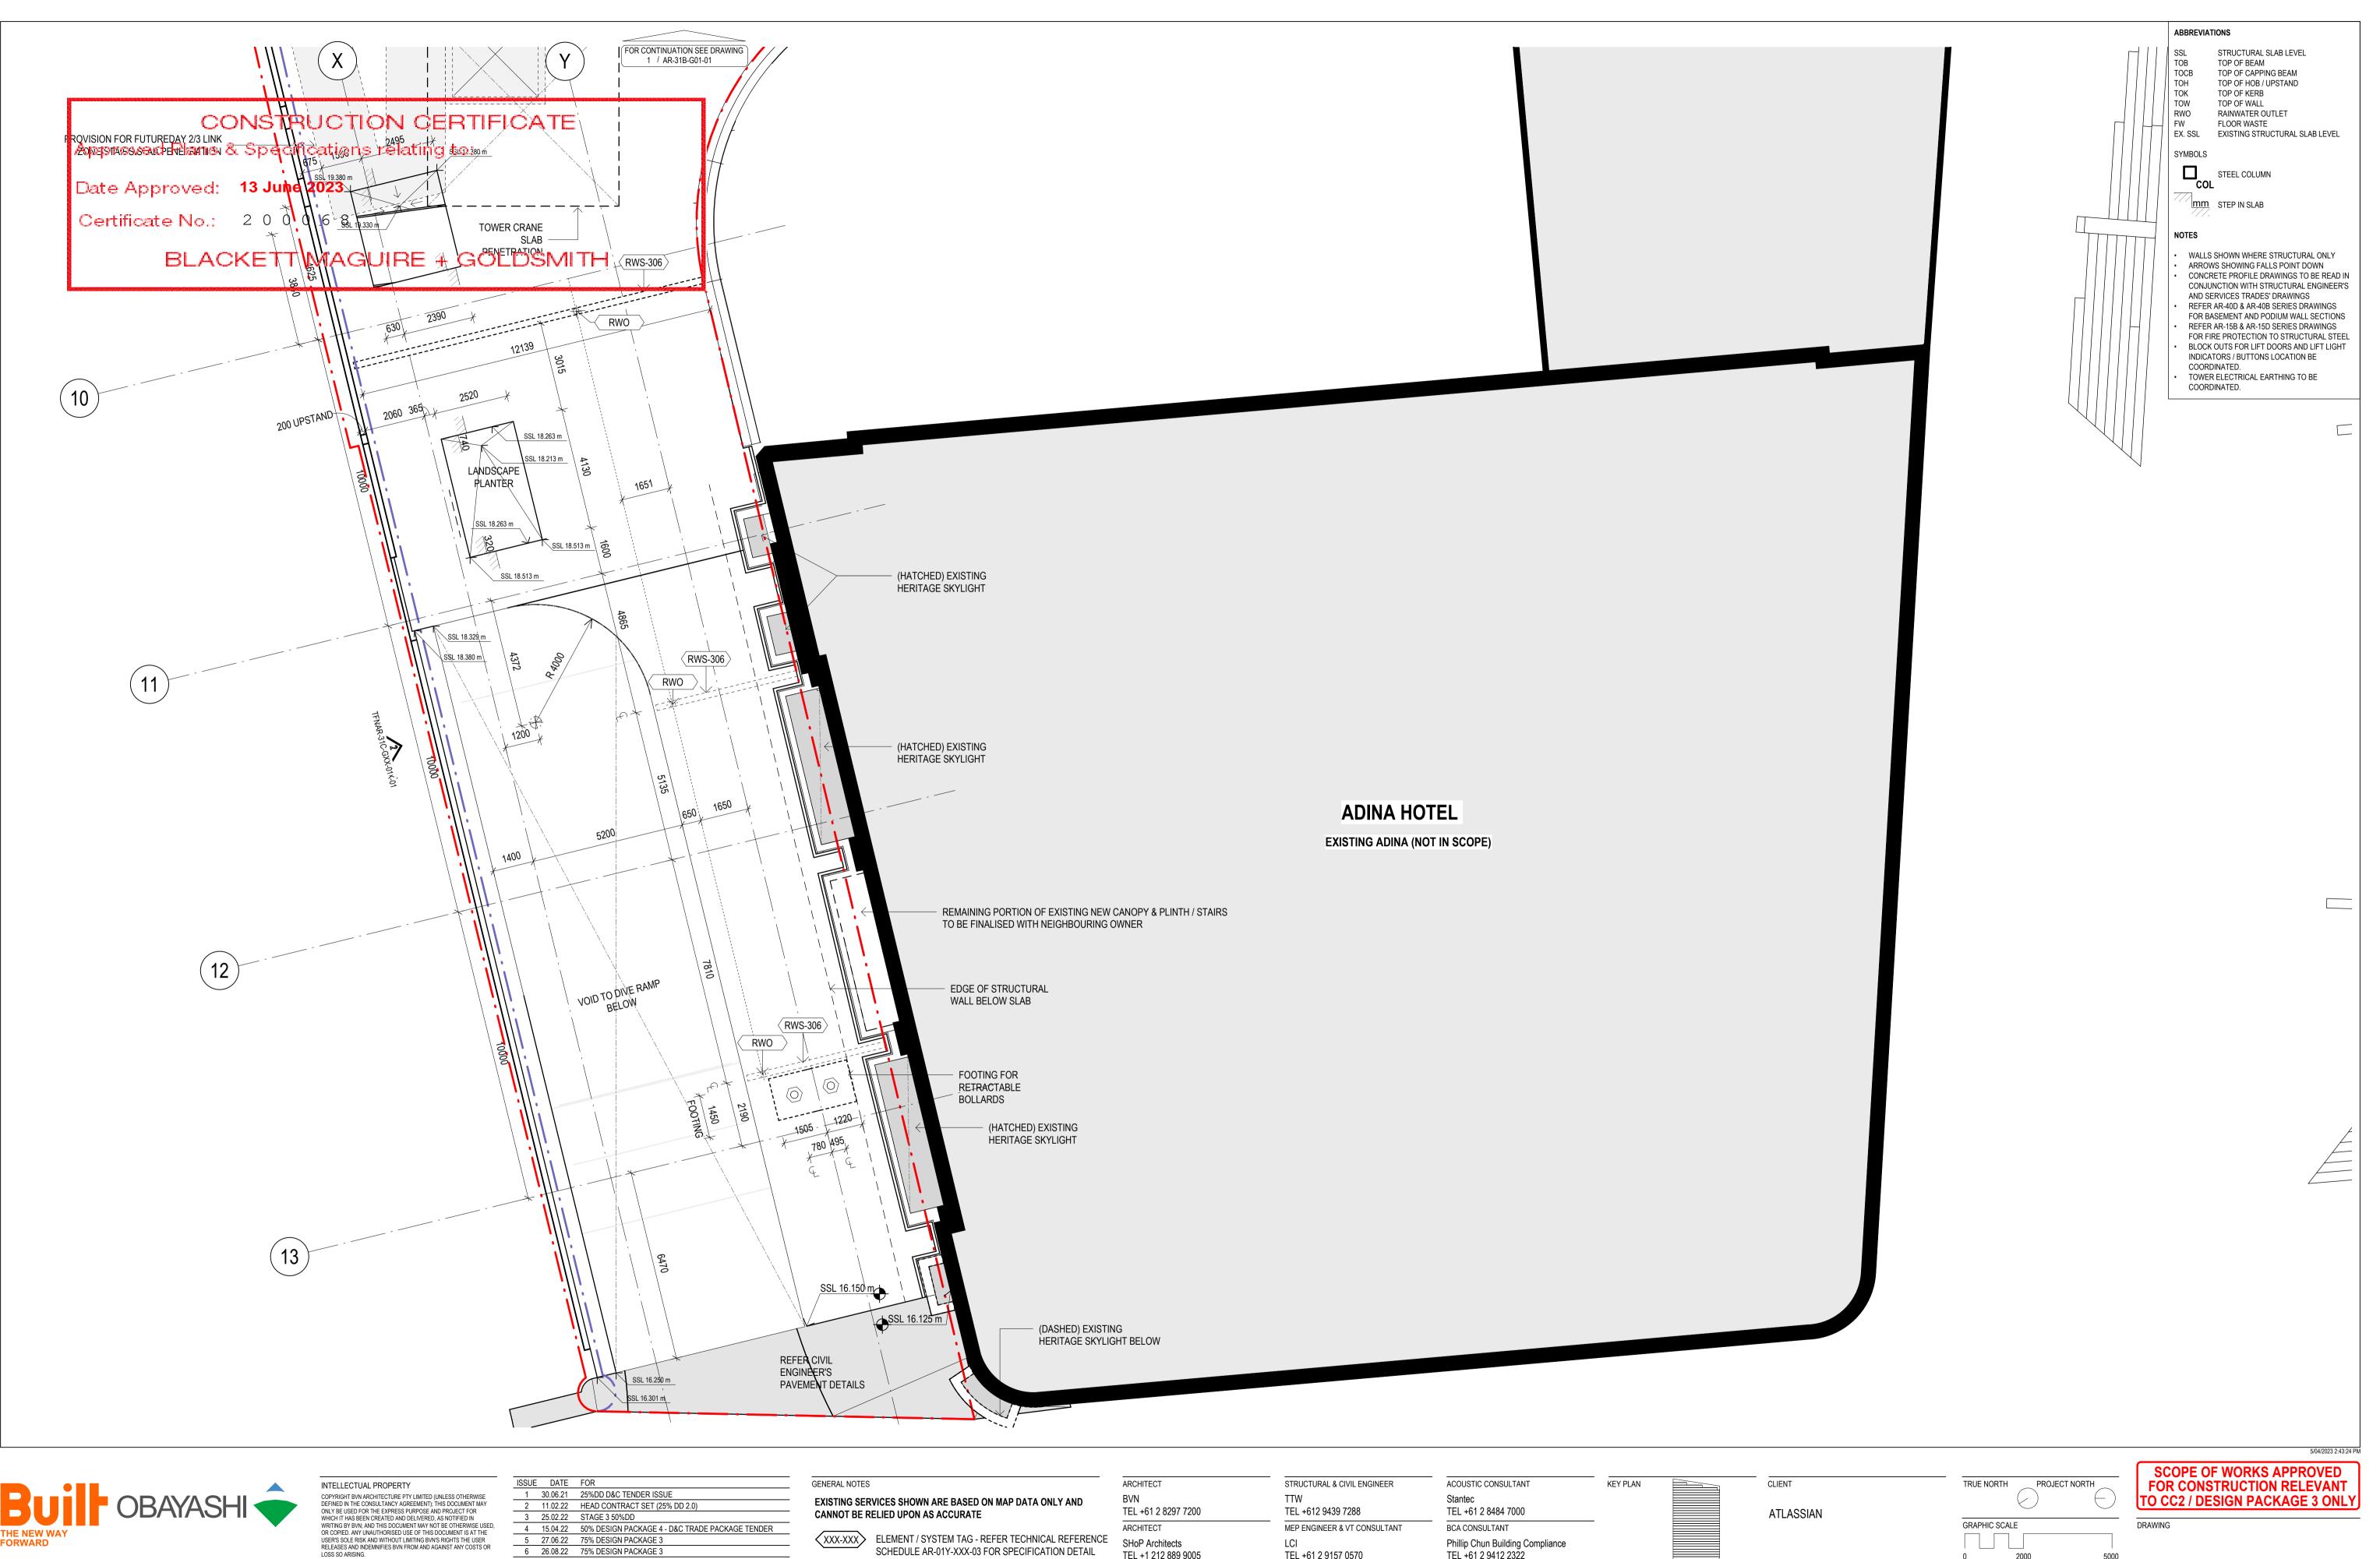



QLD STAND TO THE STAND THE STAN 7115 JULIAN ASHTON 7053 MATTHEW BLAIR 7151 PHILLIP ROSSINGTON 7439 PETER TITMUSS 10447 ALISON BOUNDS 10705 CATHERINE SKINNER Phone: +61 2 8297 7200 Fax: +61 2 8297 7299 Website: www.bvn.com.au LOSS SO ARISING.

CONTRACTOR TO CHECK AND VERIFY ALL DIMENSIONS ON SITE PRIOR TO COMMENCEMENT OF WORK OR PREPARATION OF SHOP DRAWINGS. DO NOT SCALE THIS DRAWING

ORIGINAL DRAWING

IN COLOUR

5 27.06.22 75% DESIGN PACKAGE 3 6 26.08.22 75% DESIGN PACKAGE 3 A 23.11.22 AFC DESIGN PACKAGE 3 B 28.03.23 AFC CC2 / DP3

> LXX.DXX) DOOR TAG; REFER DOOR SCHEDULES WALL TAG; REFER INTERNAL WALL TYPES SCHEDULE AR-52A-XXX-01

SHoP Architects TEL +1 212 889 9005 FWT-XXX EXTERNAL WALL SYSTEM CODE - REFER AR-43 SERIES FOR SCOPE, & FACADE ENGINEER'S DOCUMENTS FOR TOWN PLANNER TEL +61 2 8233 9900 LANDSCAPE ARCHITECT ASPECT Studios TEL +61 2 9699 7182

TEL +61 2 9157 0570 TEL +61 2 8484 7000 FIRE ENGINEER Holmes Fire TEL +61 2 9264 4658

Phillip Chun Building Compliance TEL +61 2 9412 2322 ELECTRICAL, FIRE SAFETY & HYDRAULIC DDA CONSULTANT Morris Goding Access Consulting TEL +61 2 9692 9322

PROJECT MANAGER Generate TEL +61 433 706 275

PROJECT ATLASSIAN CENTRAL No.8-10 LEE STREET, HAYMARKET PROJECT NUMBER

1906024

2000 SCALE 1:100@A1 STATUS

FOR CONSTRUCTION

CONCRETE SETOUT PLAN **UPPER GROUND PART 2** DOCUMENT NUMBER

AR-31B-G01-02

SPECIFICATION DETAIL

